

ADDENDUM NO. 03

**Baggage Screening Improvements – Phase 2A**  
**[Loading Dock Reconfiguration, Sheriff’s Checkpoint Removal, Jetway Installation**  
**(Gate 30, 46, 47), IAB Airside Trash Remodel, North Checkpoint Relocation]**

PROJECT NO. A044-09002

OFFICIAL NOTICE NO. 6640

GENERAL MITCHELL INTERNATIONAL AIRPORT  
Milwaukee County, Wisconsin

Prepared By: MILWAUKEE COUNTY DEPARTMENT OF PUBLIC WORKS  
ARCHITECTURE AND ENGINEERING DIVISION  
Airport Engineers - Telephone 414-747-5320  
5300 South Howell Avenue  
Milwaukee, Wisconsin 53207

DATE OF ADDENDUM: June 14, 2011

BIDS CLOSE: 2:00 P.M., WEDNESDAY June 22, 2011

-----  
TO ALL BIDDERS:

Each bidder shall read this Addendum in its entirety to determine to what extent his proposal and the contract conditions will be affected. This Addendum to the Contract Documents is issued to modify, explain, or correct the original documents and is hereby made part of the Contract Documents.

-----  
RECEIPT - Sign the following receipt and attach to submitted Proposal Form.

-----  
Receipt of Addendum No. 3, consisting of two (9) pages, for **Baggage Screening Improvements – Phase 2A**, [Loading Dock Reconfiguration, Sheriff’s Checkpoint Removal, Jetway Installation (Gate 30, 46, 47), IAB Airside Trash Remodel, North Checkpoint Relocation], Official Notice No. 6640, at General Mitchell International Airport, Milwaukee, Wisconsin, dated May 26, 2011 is acknowledged.

Date \_\_\_\_\_

Firm \_\_\_\_\_

Per \_\_\_\_\_

Address \_\_\_\_\_

## CHANGES

### SPECIFICATIONS

None.

### DRAWINGS

#### Electrical

**E101A:** Changed drawing scale in plan view **2/E101A** for clarity. (refer to attached drawing)

**E104A:** In Detail **1/E104A**, deleted feeder from S6/5 to Gate D30. Clarification for the location of the feeder to gates 46 and 47 (refer to attached drawing). Revise sheet note 9 as shown in attached drawing.


**E105A:** In detail **1/E105A**, added feeder from disconnect switch to PSS4/L (refer to attached drawing). Revised the route of the communications cable to room 110A (refer to attached drawing).

**E600A:** Revised one line diagram in detail **1/E600A** to reflect the change to the deletion of the feeder to gate D30 (refer to attached drawing).


**E701A:** Revised the one line diagram **2/E701A** to show the new feeder for Gate D46 and 47 (refer to attached drawing).  
Adding a new one line diagram in detail **5/E701A** for the feeder to gate D30 (refer to attached drawing).

### CLARIFICATIONS

None.

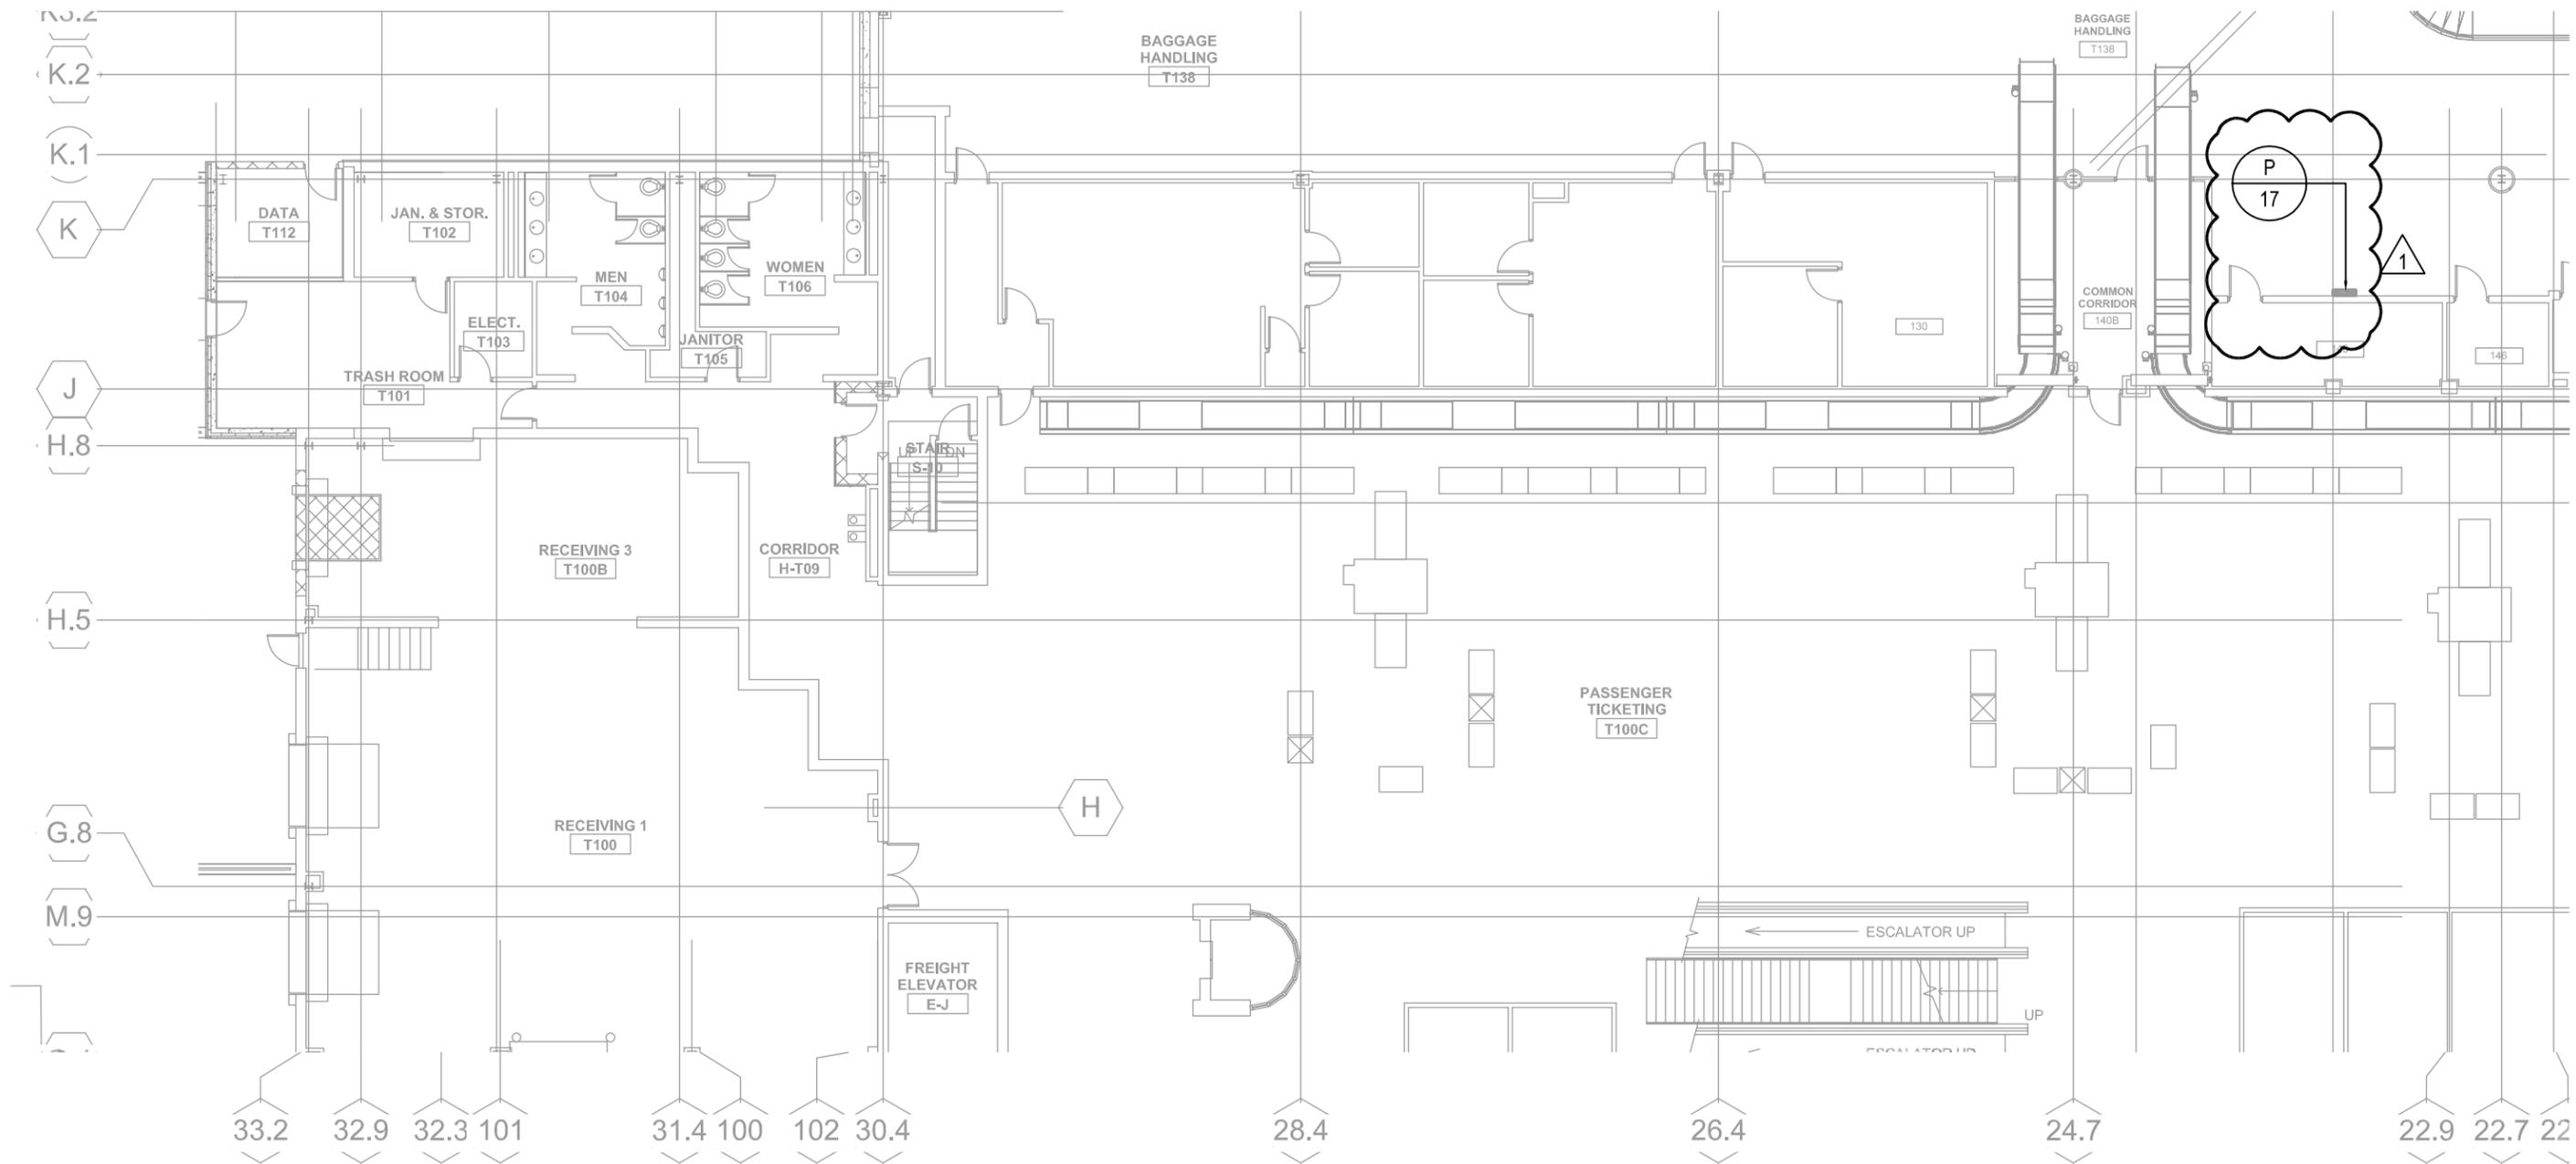

 2 PARTIAL GRADE LEVEL PLAN NORTH - PANEL "P/17" LOCATION  
 1/16"=1'-0" 3



MILWAUKEE COUNTY DEPARTMENT OF  
 TRANSPORTATION AND PUBLIC WORKS


CITY CAMPUS 2711 W. WELLS ST - 2ND FLOOR MILWAUKEE, WI 53208

PROJECT NUMBER: A0044-09002  
 DATE: 06/14/11  
 SCALE: 1/16"=1'-0"  
 SHEET TITLE: PARTIAL SITE PLAN SECURITY GATE 9L  
 AND GUARD HOUSE - POWER AND SYTEMS

PROJECT TITLE: GENERAL MITCHELL INTERNATIONAL  
 AIRPORT BAGGAGE SCREENING  
 IMPROVEMENTS PHASE 2A

ADDENDUM #03


**E101A**

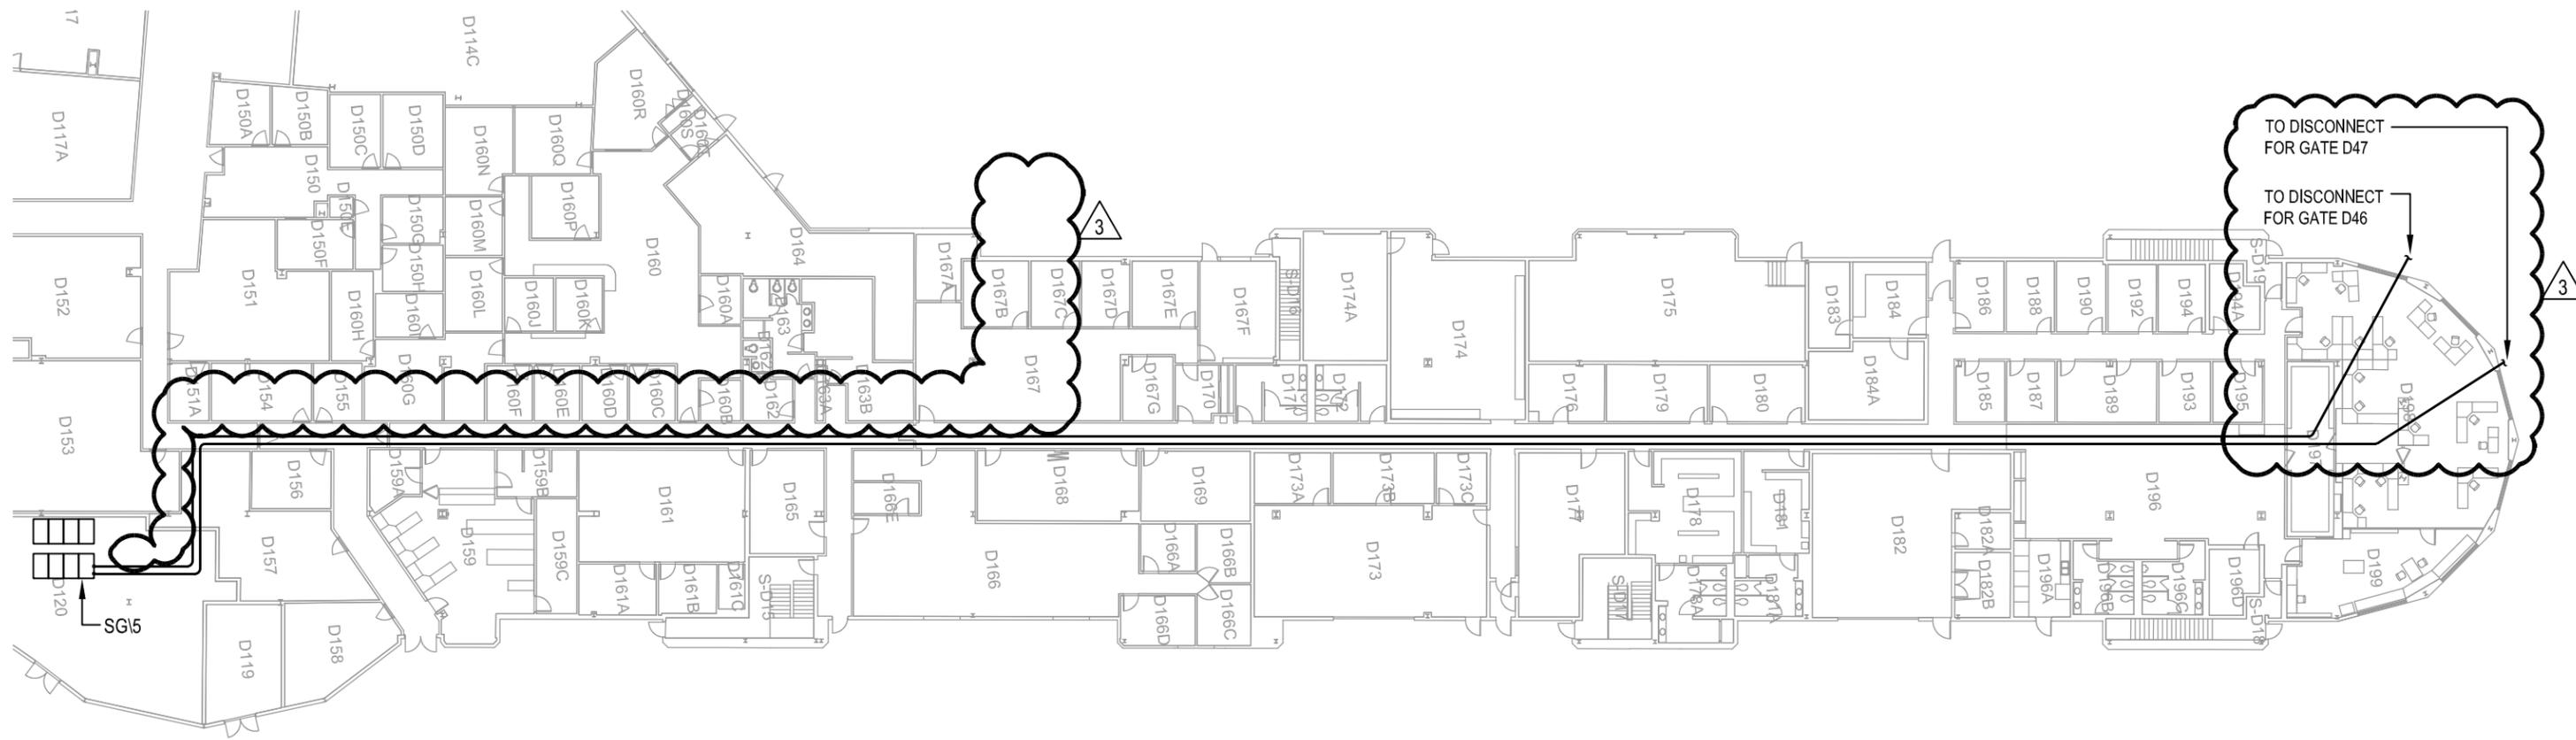

2

### CONDUIT ROUTE FOR CONCOURSE D GATES D30, D46 & D47

 1/32"=1'-0"



MILWAUKEE COUNTY DEPARTMENT OF  
TRANSPORTATION AND PUBLIC WORKS


CITY CAMPUS 2711 W. WELLS ST - 2ND FLOOR MILWAUKEE, WI 53208

PROJECT NUMBER: A0044-09002  
 DATE: 06/14/11  
 SCALE: 1/32"=1'-0"  
 SHEET TITLE: CONDUIT ROUTE FOR CONCOURSE D GATES D30, D46 & D47

PROJECT TITLE: GENERAL MITCHELL INTERNATIONAL  
 AIRPORT BAGGAGE SCREENING  
 IMPROVEMENTS PHASE 2A

ADDENDUM #03


# E104A

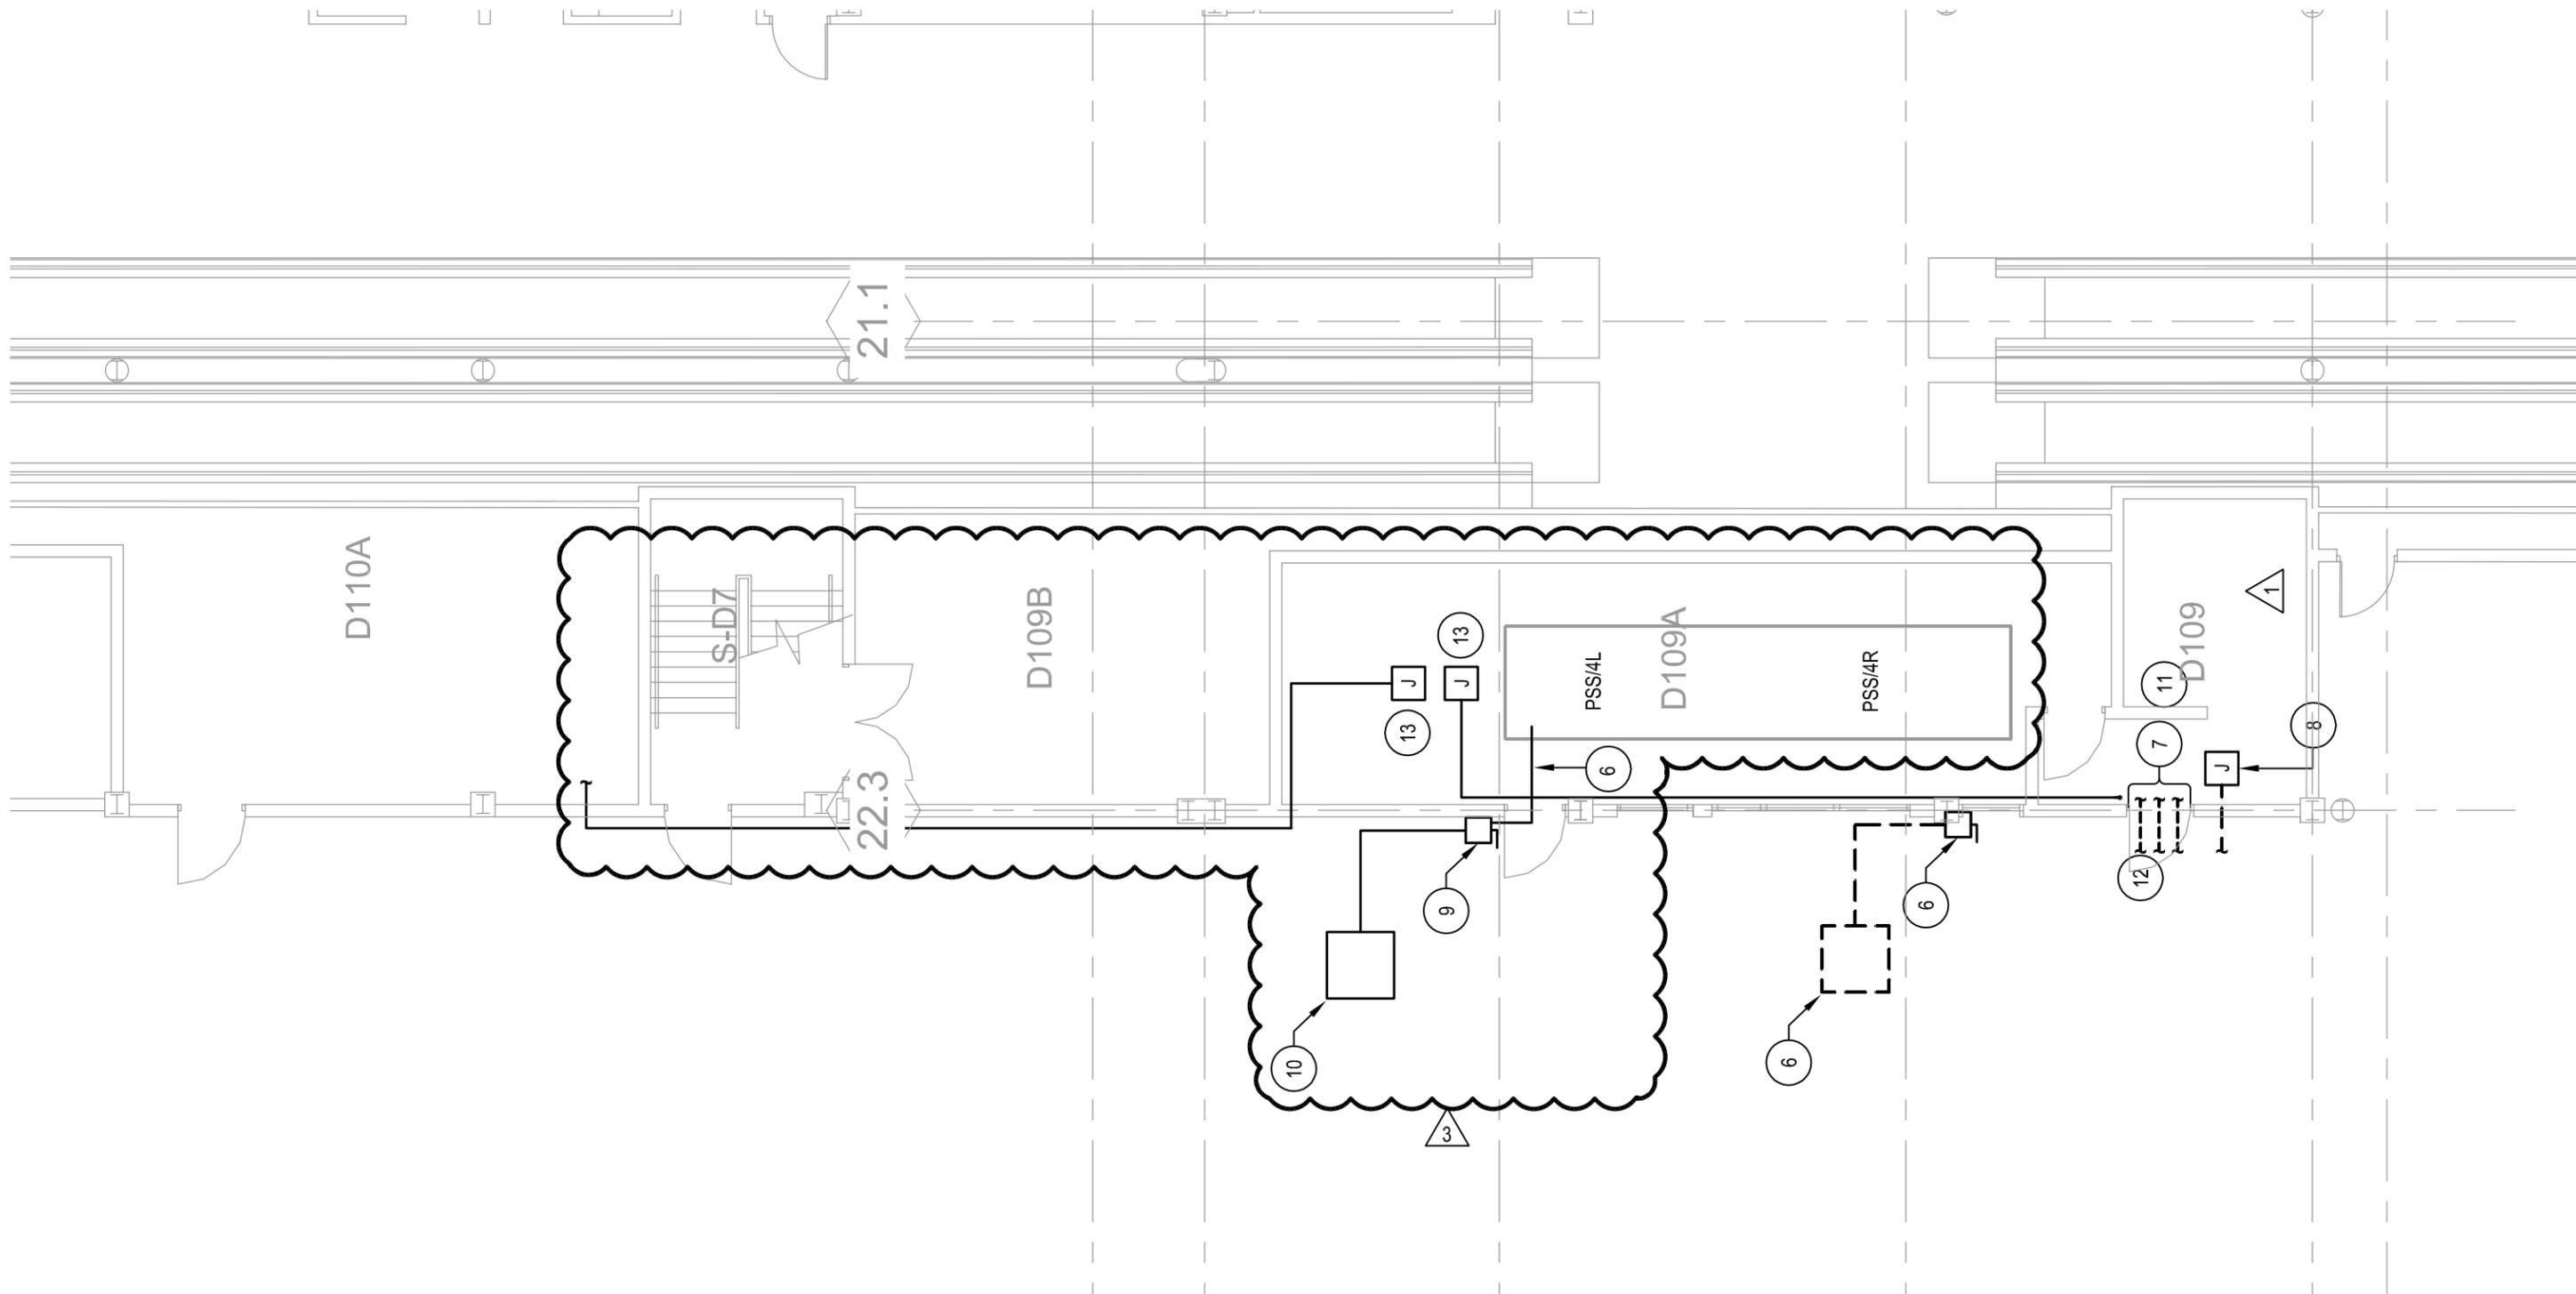

1

**PARTIAL GRADE LEVEL CONCOURSE D GATE  
D30 - POWER AND SYSTEMS**

1/8"=1'-0"

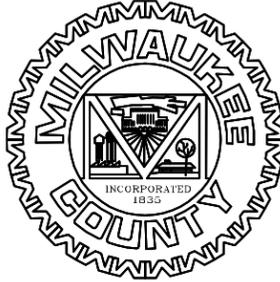

**MILWAUKEE COUNTY DEPARTMENT OF  
TRANSPORTATION AND PUBLIC WORKS**  
CITY CAMPUS 2711 W. WELLS ST - 2ND FLOOR MILWAUKEE, WI 53208

PROJECT NUMBER: A044-09002  
DATE: 06/14/11  
SCALE: 1/8"=1'-0"  
SHEET TITLE: PARTIAL GRADE LEVEL CONCOURSE D  
GATE D30 - POWER AND SYSTEMS


PROJECT TITLE: GENERAL MITCHELL INTERNATIONAL  
AIRPORT BAGGAGE SCREENING  
IMPROVEMENTS PHASE 2A

ADDENDUM #03

**E105A**

## SHEET NOTES:

- 1 DISCONNECT AND REMOVE EXISTING SIGN. RETAIN FOR RELOCATION. AS SHOWN ON THIS SHEET.
- 2 DISCONNECT AND REMOVE EXISTING CARD READER AND EXIT SWITCH. RETAIN FOR RELOCATION AS SHOWN ON THIS SHEET.
- 3 RELOCATE EXISTING SIGN TO NEW LOCATION. EXTEND EXISTING CONDUCTORS AND CONDUIT AND CONNECT.
- 4 EXTEND EXISTING SIGNAL CABLES FOR CARD READER TO NEW LOCATION AND CONNECT.
- 5 PROVIDE (2) 1 1/2" CONDUITS FROM NEW JUNCTION BOXES STUBBED UP THROUGH FLOOR FOR FUTURE PEDESTAL. VERIFY EXACT LOCATION WITH OWNER. EC SHALL CAP AND LABEL CONDUITS.
- 6 DISCONNECT JET BRIDGE FROM EXISTING DISCONNECT. REMOVE ALL CONDUIT AND WIRING FROM DISCONNECT TO JET BRIDGE.
- 7 DISCONNECT AND REMOVE EXISTING WIRING AND CONDUIT TO JET BRIDGE BACK TO SOURCE. PATCH OPENING IN WALL.
- 8 DISCONNECT AND REMOVE EXISTING WIRING AND CONDUIT BACK TO JUNCTION BOX. MARK ALL CONDUCTORS AS SPARE AND IDENTIFY SOURCE.
- 9 PROVIDE NEW 400A/3P DISCONNECT SWITCH GEAR PSS/4L.  CONNECT TO SPARE 400A/3P BREAKER IN  
- 10 PROVIDE MOUNTING STRUCTURE, PANELS, WIRING AND CONNECTIONS FOR JET BRIDGE AS SHOWN IN DETAIL 3/E701A.
- 11 PROVIDE 1" CONDUIT WITH 4 CAT 6 CABLES FROM JUNCTION BOX TO ROOM D201A. STUB UP THROUGH CEILING AND LEAVE 15' SPARE CABLE COILED IN ROOM D201A.
- 12 PROVIDE 2 312, #12 GND IN 3/4" CONDUIT FROM PANEL 2/LA IN ROOM D201A TO JUNCTION BOX.
- 13 LEAVE 10' OF SPARE CABLE IN JUNCTION BOX FOR FUTURE CONNECTION TO PODIUM.

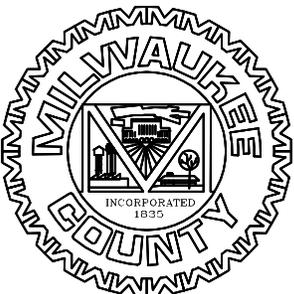

### MILWAUKEE COUNTY DEPARTMENT OF TRANSPORTATION AND PUBLIC WORKS

CITY CAMPUS 2711 W. WELLS ST - 2ND FLOOR MILWAUKEE, WI 53208


PROJECT NUMBER: A044-09002  
DATE: 06/14/11  
SCALE: AS NOTED  
SHEET TITLE: SHEET NOTES

PROJECT TITLE: GENERAL MITCHELL INTERNATIONAL  
AIRPORT BAGGAGE SCREENING  
IMPROVEMENTS PHASE 2A

ADDENDUM #03

# E105A


D-CONCOURSE  
HAMMERHEAD RM D120

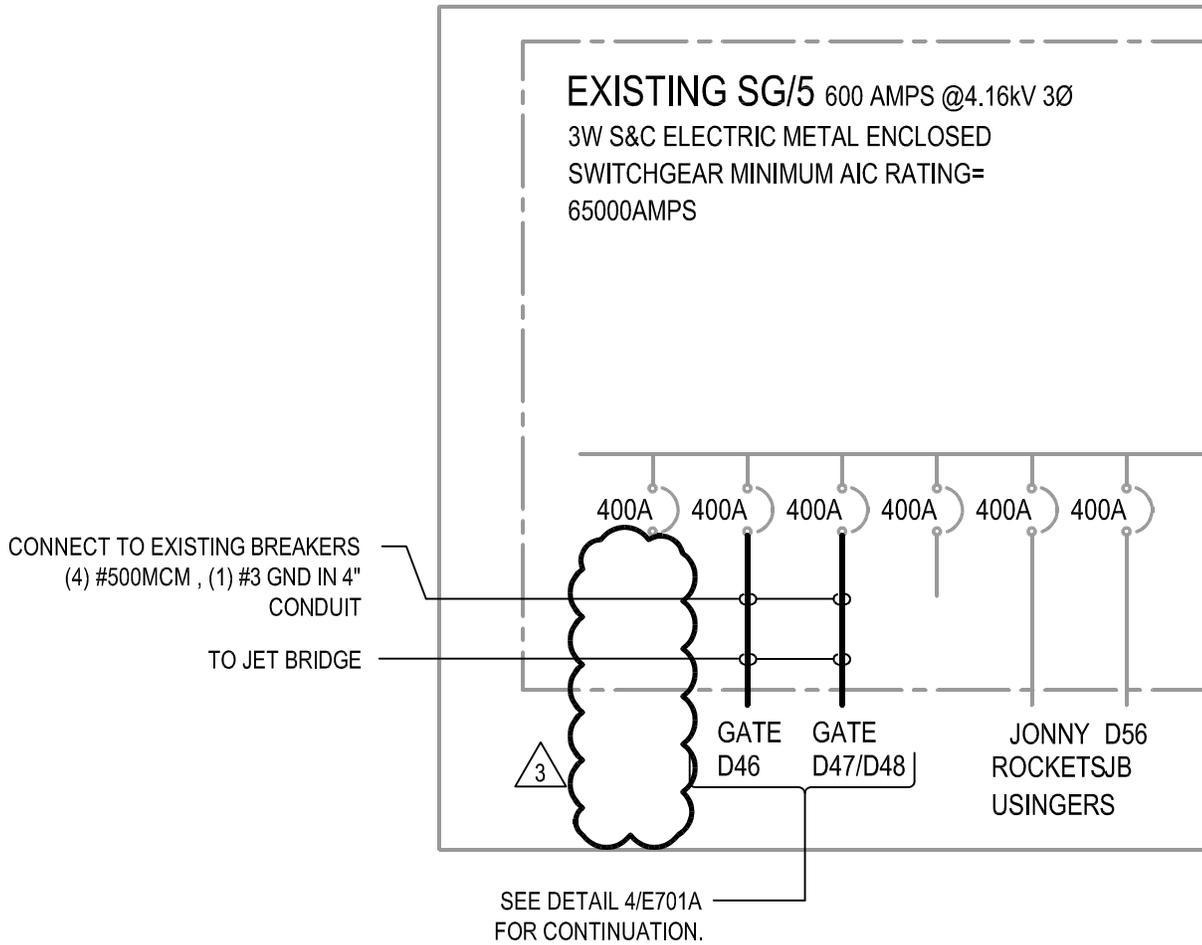

1

JETBRIDGE ONE LINE DIAGRAMS

NO SCALE

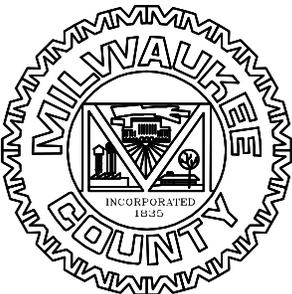

MILWAUKEE COUNTY DEPARTMENT OF  
TRANSPORTATION AND PUBLIC WORKS


CITY CAMPUS 2711 W. WELLS ST - 2ND FLOOR MILWAUKEE, WI 53208

PROJECT NUMBER: A044-09002  
DATE: 06/14/11  
SCALE: No Scale  
SHEET TITLE: ONE LINE DIAGRAMS

PROJECT TITLE: GENERAL MITCHELL INTERNATIONAL  
AIRPORT BAGGAGE SCREENING  
IMPROVEMENTS PHASE 2A

ADDENDUM #03

**E600A**

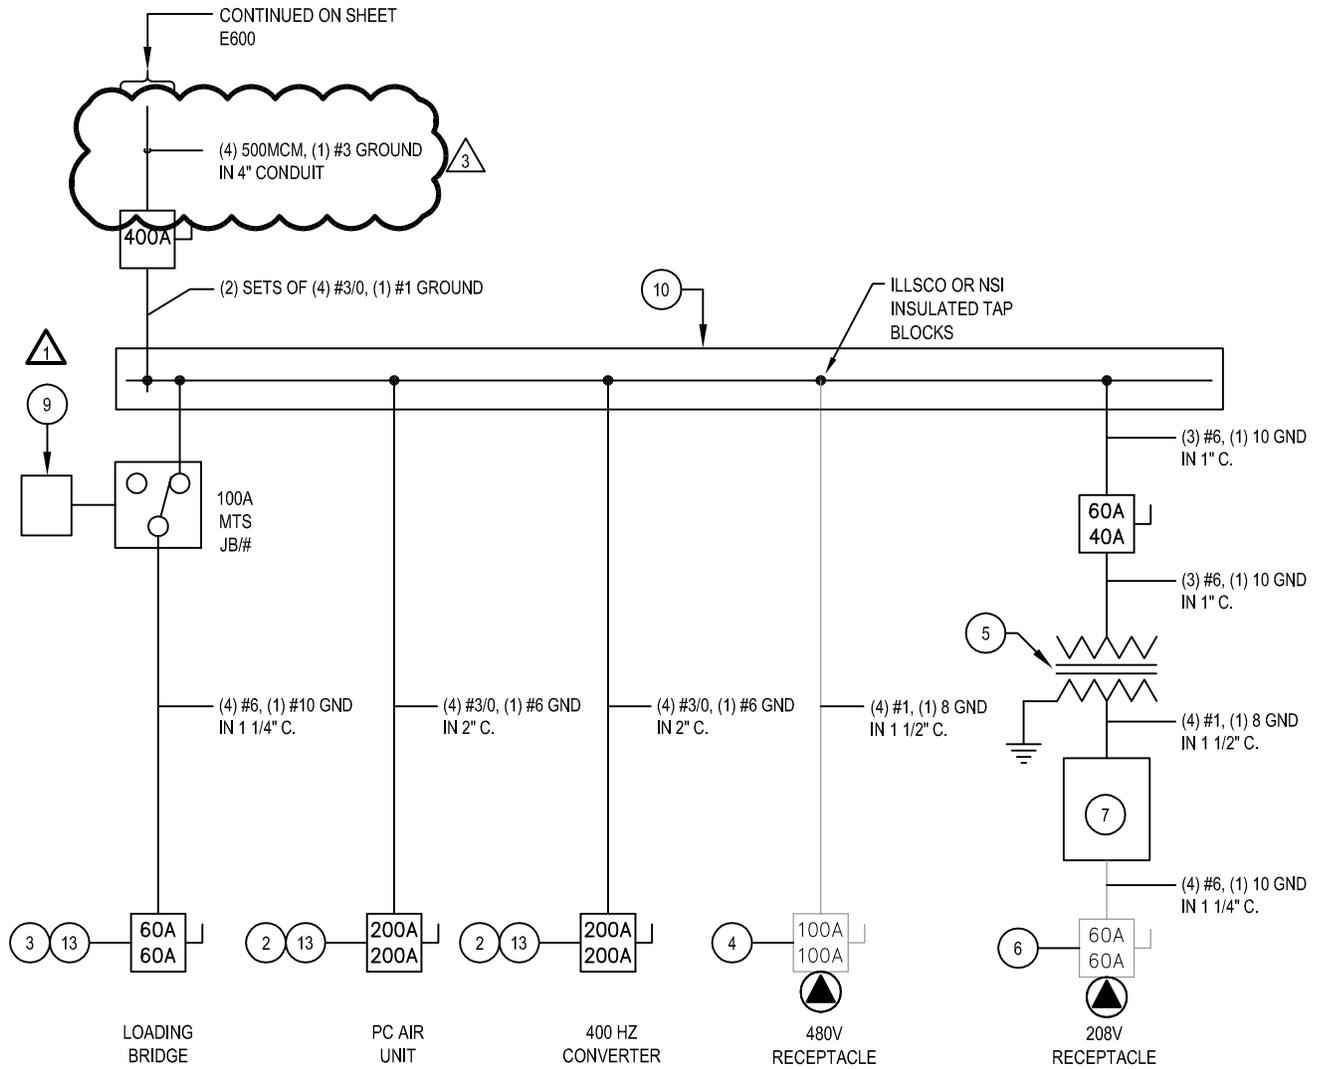


**NOTE:**  
 WIRING AND CONNECTIONS FROM FUSIBLE DISCONNECTS  
 TO THE JETWAY IS NOT IN THIS CONTRACT.

2  
 E701A

**GATE D46 AND D47/D48 JET BRIDGE ELECTRICAL POWER ONE LINE DIAGRAM**

NOT TO SCALE

3

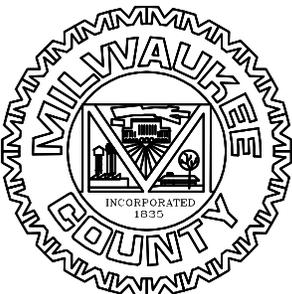

**MILWAUKEE COUNTY DEPARTMENT OF  
 TRANSPORTATION AND PUBLIC WORKS**

CITY CAMPUS 2711 W. WELLS ST - 2ND FLOOR MILWAUKEE, WI 53208



PROJECT NUMBER: A044-09002 PROJECT TITLE: GENERAL MITCHELL INTERNATIONAL AIRPORT BAGGAGE SCREENING IMPROVEMENTS PHASE 2A ADDENDUM #03

DATE: 06/14/11

SCALE: NTS

SHEET TITLE: JET BRIDGE ELECTRICAL POWER ONE LINE DIAGRAM


**E701A**

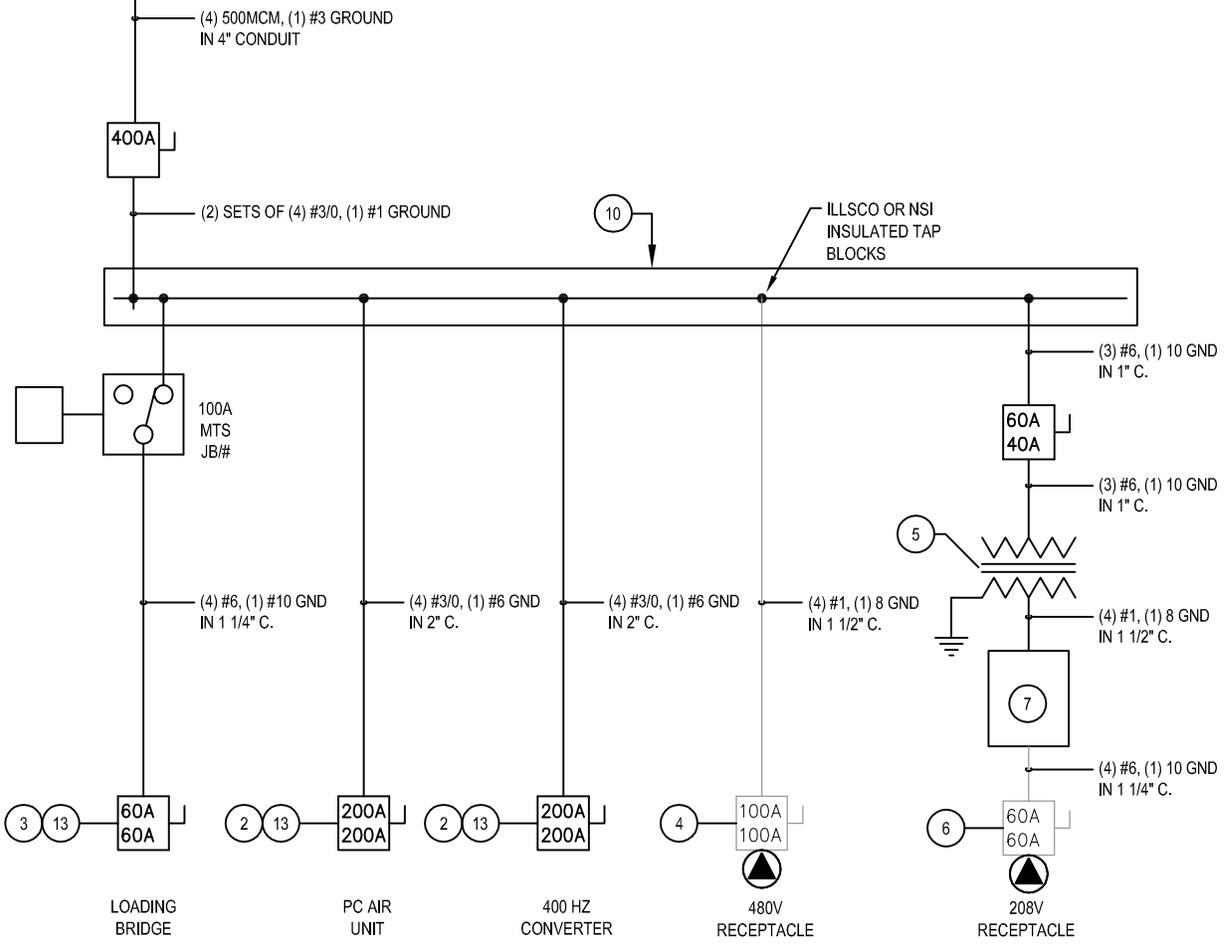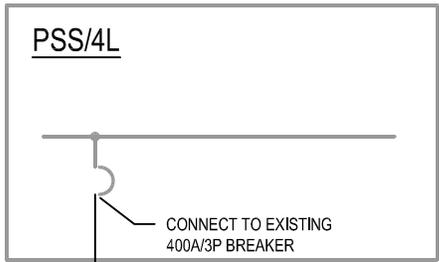

**NOTE:**  
 WIRING AND CONNECTIONS FROM FUSIBLE DISCONNECTS TO THE JETWAY IS NOT IN THIS CONTRACT.

5  
 E701A

**GATE D30 JET BRIDGE ELECTRICAL POWER ONE LINE DIAGRAM**  
 NOT TO SCALE

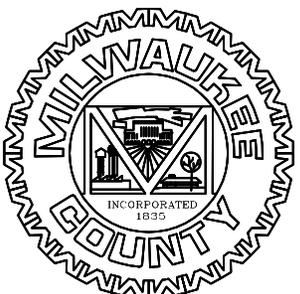

**MILWAUKEE COUNTY DEPARTMENT OF TRANSPORTATION AND PUBLIC WORKS**

CITY CAMPUS 2711 W. WELLS ST - 2ND FLOOR MILWAUKEE, WI 53208

PROJECT NUMBER: A044-09002 PROJECT TITLE: GENERAL MITCHELL INTERNATIONAL AIRPORT BAGGAGE SCREENING IMPROVEMENTS PHASE 2A ADDENDUM #03

DATE: 06/14/11

SCALE: NTS

SHEET TITLE: JET BRIDGE ELECTRICAL POWER ONE LINE DIAGRAM

**E701A**