

**ADDENDUM NUMBER:** Addendum - Three  
**PROJECT TITLE:** Milwaukee County Parks Department

**RE-BIDDING of:**  
**VETERANS PARK SHELTER**  
**Site Number: 794**  
**Building Number: 1505**  
**750 North Lincoln Memorial Drive**  
**Milwaukee, Wisconsin 53202**

**PROJECT NUMBER:** P167-10422

**DATE OF ADDENDUM:** July 16, 2013

This Addendum to the Contract Documents is issued to modify, explain or correct the Re-Bidding Construction Documents, Dated June 26, 2013, and is hereby made part of the Contract Documents. Acknowledge receipt of this addendum in the space provided on the Bid Form, or bid maybe rejected.

CLARIFICATION

Pre-Bid Meeting Discussions and Prices:

During the pre-bid meeting held July 11, 2013, comments were made by various parties in attendance related to previous bid amounts and budgets. Attendees who were not representatives of Milwaukee County made some comments relating to bid amounts and the project budget, any reference to specific budgets or budget ranges should not be considered as unsubstantiated and should NOT cause influence to a Contractor's Bid. Bids shall be made in accordance with Bidding Documents that Bidder has read and understands.

SPECIFICATIONS

DOCUMENT BDE-014 – COMMITMENT TO SUBCONTRACT WITH DBE FIRMS:  
 Revise BDE Goal: 17.3%

DRAWINGS

P-100 FOUNDATION PLUMBING PLAN AND WASTE PIPING ISOMETRIC:  
 Sanitary vent piping above ground has been revised; see attached revised WASTE PIPING ISOMETRIC,  
 Detail 2 / P-100.


END OF ADDENDUM THREE

Attachments:

DRAWINGS

Detail 2 / P-100; (revised)

H:\WORK\2013\15-1023-00 - Veterans Park Shelter\P113-1023-00\_P100.dwg

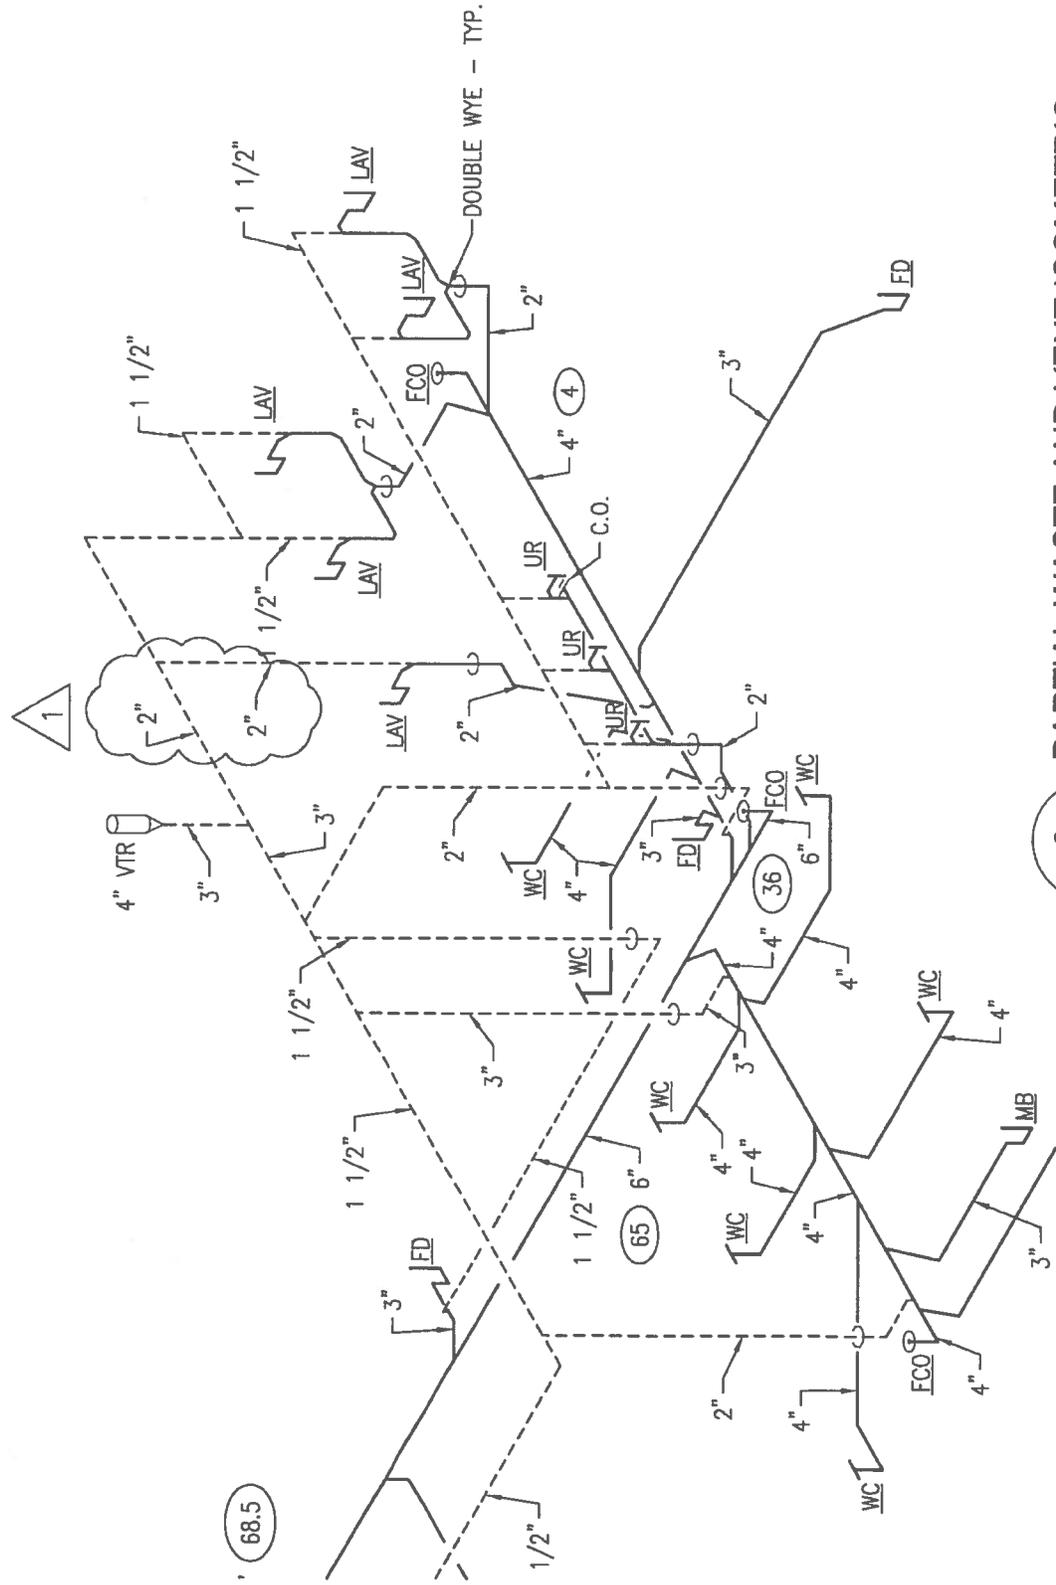

2 PARTIAL WASTE AND VENT ISOMETRIC  
P-100 NTS



**Milwaukee County Parks Department**  
**RE-BIDDING**  
**VETERANS PARK SHELTER**

Milwaukee Dept. of Administrative Services  
FACILITIES MANAGEMENT DIVISION  
Architectural, Engineering & Environmental Services  
CITY CAMPUS 2711 W WELLS ST. 2ND FLOOR MILWAUKEE, WI 53288

REVISIONS  
1 VENT PIPE SIZE CHANGES.

DATE: 7/11/2013  
PROJECT: P167-10422  
SITE NO: 794  
BUILDING NO: 1505  
SHEET NO:

ADD.3-P1