

P487-15645  
P488-15646  
P489-15647

**ADDENDUM NUMBER:**

**Addendum - Six**

**PROJECT TITLE:**

**MCGOVERN PARK**

Restroom Facility and Detached Pavilion  
Site Number: 699  
Building Number: 1410  
5400 North 51st. BLVD  
Milwaukee, Wisconsin 53218  
Project Number: P487-15645

**KERN PARK**

Restroom Facility with Attached Pavilion  
Site Number: 691  
Building Number: 1280  
3614 North Humboldt BLVD.  
Milwaukee, Wisconsin 53212  
Project Number: P488-15646

**DOCTORS PARK**

Restroom Facility with Attached Pavilion  
Site Number: 685  
Building Number: 1040  
1870 East Fox Lane  
Bayside, Wisconsin 53217  
Project Number: P489-15647

**DATE OF ADDENDUM: March 01, 2016**

This Addendum to the Contract Documents is issued to modify, explain or correct the original Documents, Dated JANUARY 27, 2016 and is hereby made part of the Contract Documents. Acknowledge receipt of this addendum in the space provided on the Bid Form, or bid maybe rejected.

**DRAWINGS**

**PLUMBING:** Doctors Park – new restroom facility with attached pavilion


**SHEET P-300**

Revise: Foundation Plumbing Plan

Add 1-1/2 inch diameter sanitary vent piping below grade as indicated on attached sheet P-1.

Revise: Waste & Vent Piping Isometric

Add 1-1/2 inch diameter sanitary vent piping below grade as indicated on attached sheet P-2.

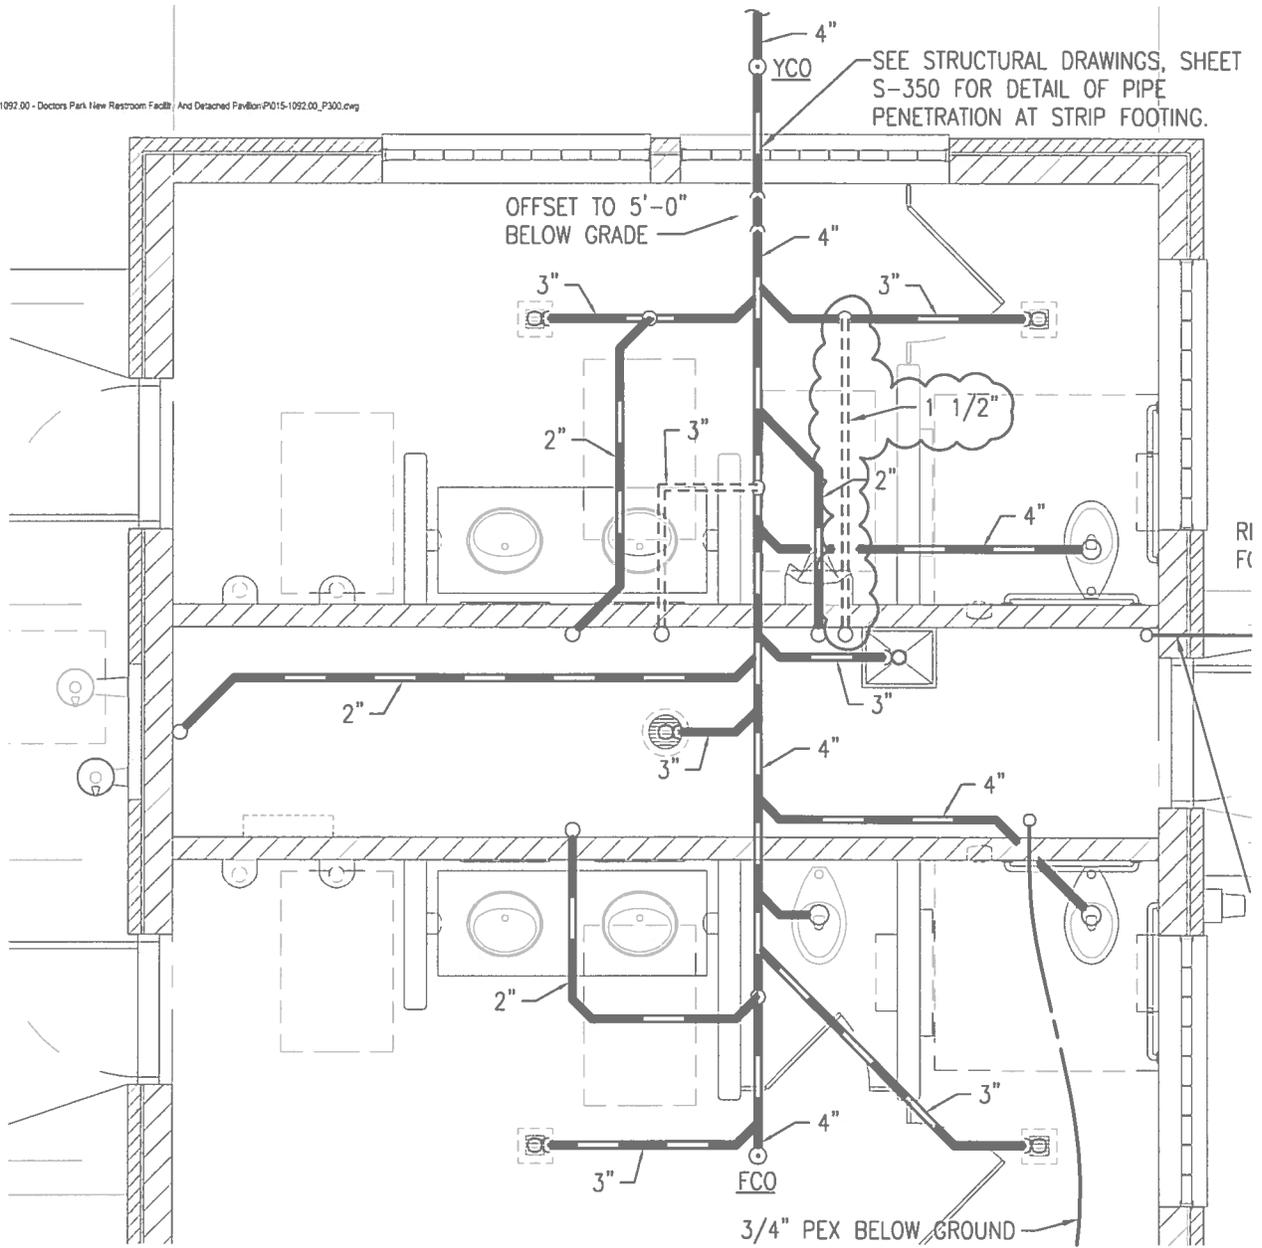

**1** FOUNDATION PLUMBING PLAN  
1/4" = 1'-0"




**P1**  
DATE: 03-01-2016  
PROJECT: P489-15647  
SITE NO.: 865  
BUILDING NO.: 1040  
SHEET NO.:

Milwaukee Dept. of Administrative Services  
FACILITIES MANAGEMENT DIVISIONS  
Architectural, Engineering & Environmental Services  
633 WEST WISCONSIN AVENUE, SUITE 1002, MILWAUKEE, WISCONSIN 53203



Milwaukee County Parks  
**DOCTORS PARK**  
1870 East Fox Lane Bayside, Wisconsin 53217

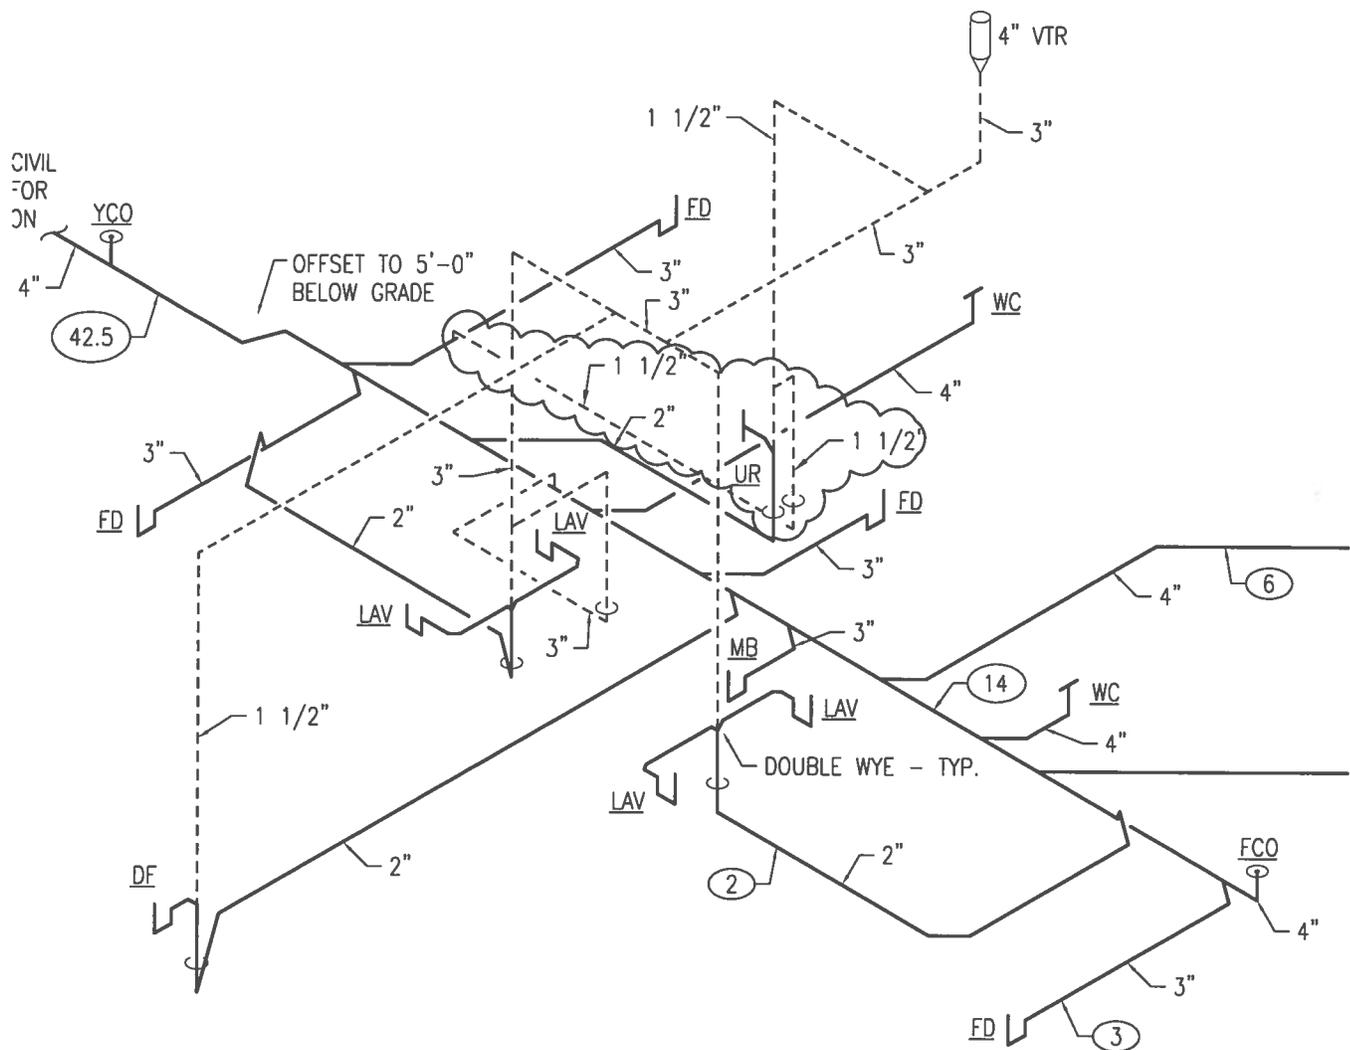

**1 WASTE & VENT PIPING ISOMETRIC**  
NTS

**P2**  
DATE: 03-01-2016  
PROJECT: P489-15647  
SITE NO: 865  
BUILDING NO: 1040  
SHEET NO:

Milwaukee Dept. of Administrative Services  
FACILITIES MANAGEMENT DIVISIONS  
Architectural, Engineering & Environmental Services  
833 WEST WISCONSIN AVENUE, SUITE 1002, MILWAUKEE, WISCONSIN 53203



Milwaukee County Parks  
**DOCTORS PARK**

1870 East Fox Lane Bayside, Wisconsin 53217