

RFP # 7131

Commercial/Industrial Building at

9150 Watertown Plank Rd- Wauwatosa, WI 53226

Questions and Answers

9-21-16



1. Maps of existing utilities in the area, in particular the power plant steam and chilled water lines.

See Attachments



They are for QUICK REFERENCE ONLY and are subject to change and should be field verified and not used for planning, engineering and any excavation work.

MATCH SHEET 7
MATCH SHEET 13

ALL DUCT LINES
4 INCHES UNLESS
OTHERWISE NOTED

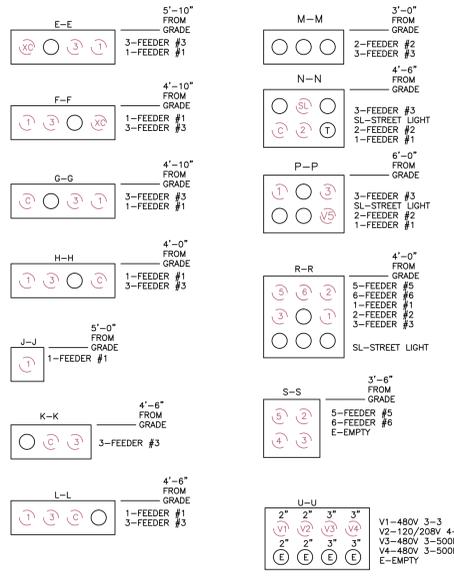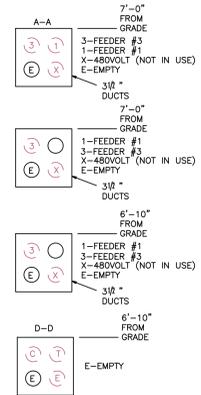


NOTE:
C-CONTROL
ABANDONED, TEMPORARY IN DUCTS.
SECTIONS D-D, E-E, F-F, G-G, H-H,
K-K, L-L, M-M, N-N, P-P, & R-R.

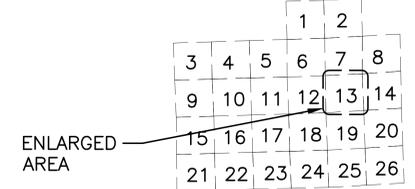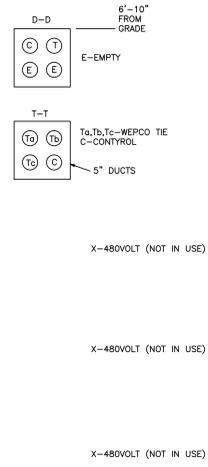

ENLARGED
AREA

KEY PLAN


NOTE:
THE INFORMATION PROVIDED ON THIS DRAWING REPRESENTS EXISTING
INFRASTRUCTURE KNOWN BY MILWAUKEE COUNTY DEPARTMENT OF PUBLIC
WORKS. THIS DRAWING AND THE INFORMATION PROVIDED ARE INTENDED TO
AID MILWAUKEE COUNTY DEPARTMENT OF PUBLIC WORKS OPERATIONAL
FUNCTIONS. THIS DRAWING SHALL NOT BE REFERENCED OR USED FOR NEW
DESIGN AND/OR CONSTRUCTION. THE INFRASTRUCTURE INFORMATION ON THIS
DRAWING SHALL BE FIELD VERIFIED.

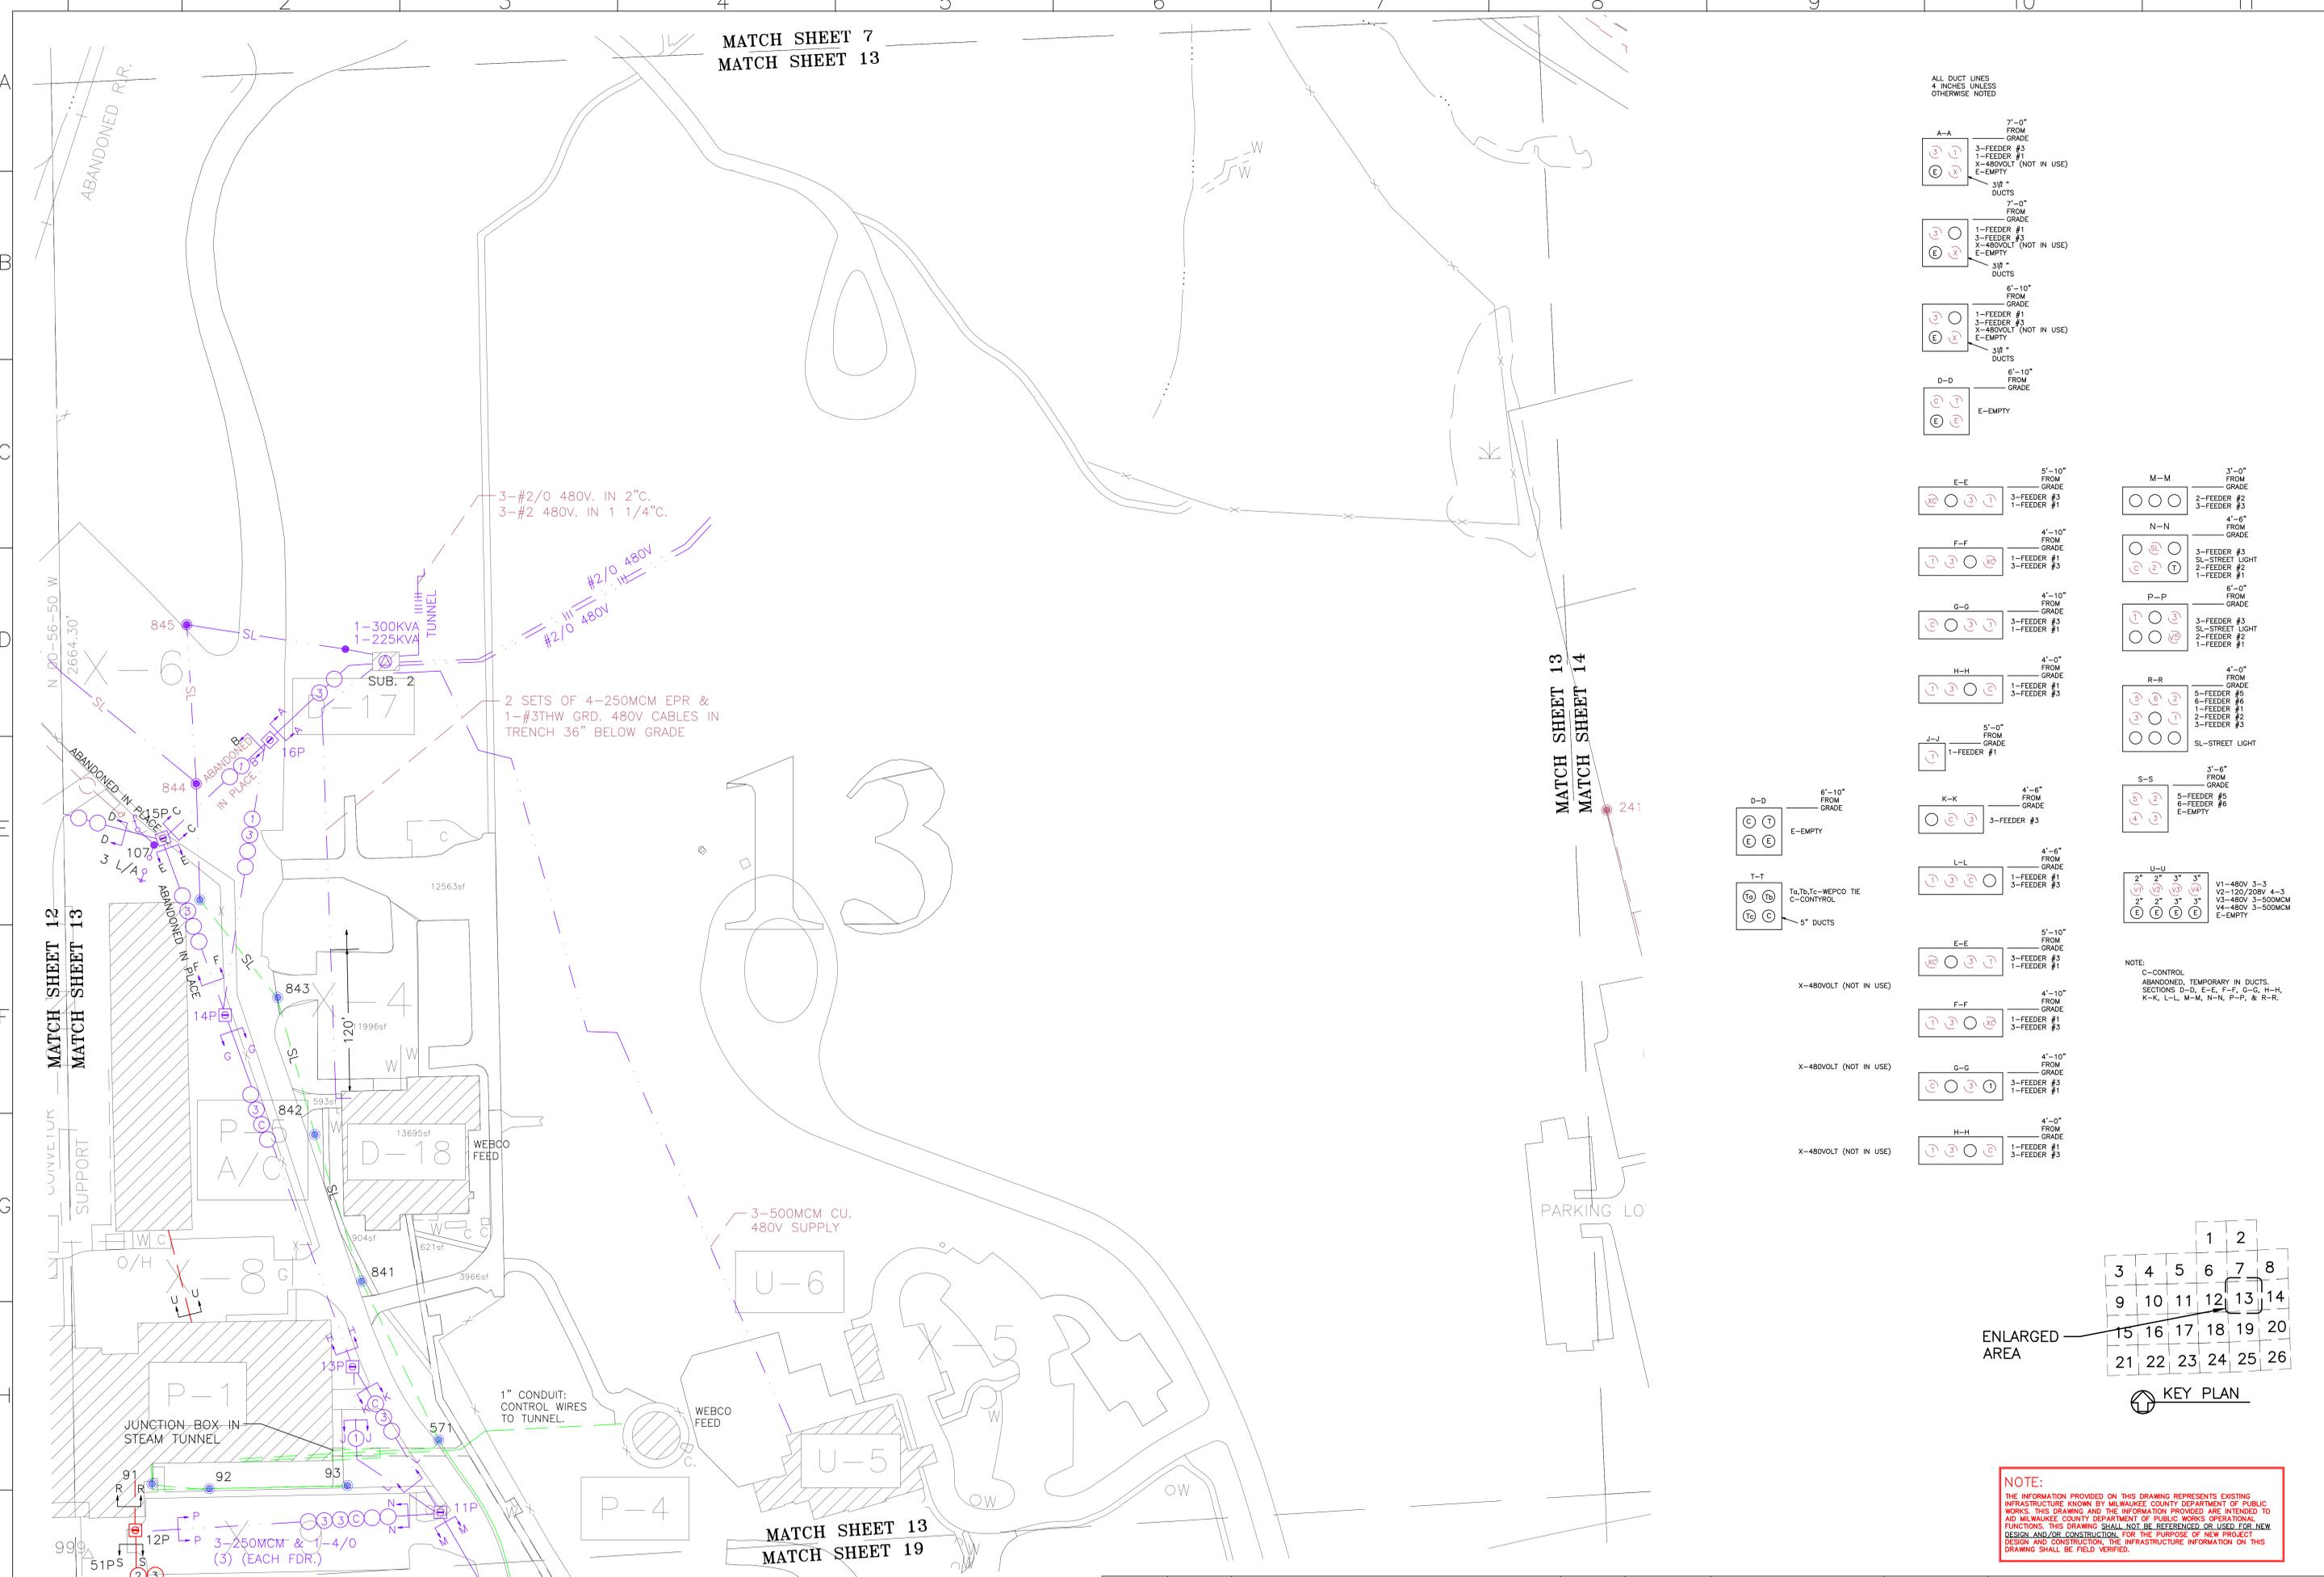

MATCH SHEET 13
MATCH SHEET 19




SHEET NO. 13 OF 26	PROJECT NO. EL13	TITLE MILWAUKEE COUNTY GROUNDS 4160 ELECTRICAL SYSTEM MAP	SCALE: 1"=50'	DRAWN BY: BRB / MJS	REVISIONS		PREPARED BY: DTPW SUPPORT SERVICES-GIS SECTION FOR MILWAUKEE COUNTY DEPARTMENT OF TRANSPORTATION AND PUBLIC WORKS 10310 WATERTOWN PLANK ROAD MILWAUKEE, WISCONSIN 53226
SHEET SIZE E	FILE NO.	DATE: 06/13/12	CHECKED BY: JOHN B.	7/14/00 UTILITY SYMBOLS 2/26/00 CHANGE TITLE BOX 5/28/00 GENERAL REVISION 6/20/00 PREP FOR REVIEW 06/13/12 GENERAL REVISION			

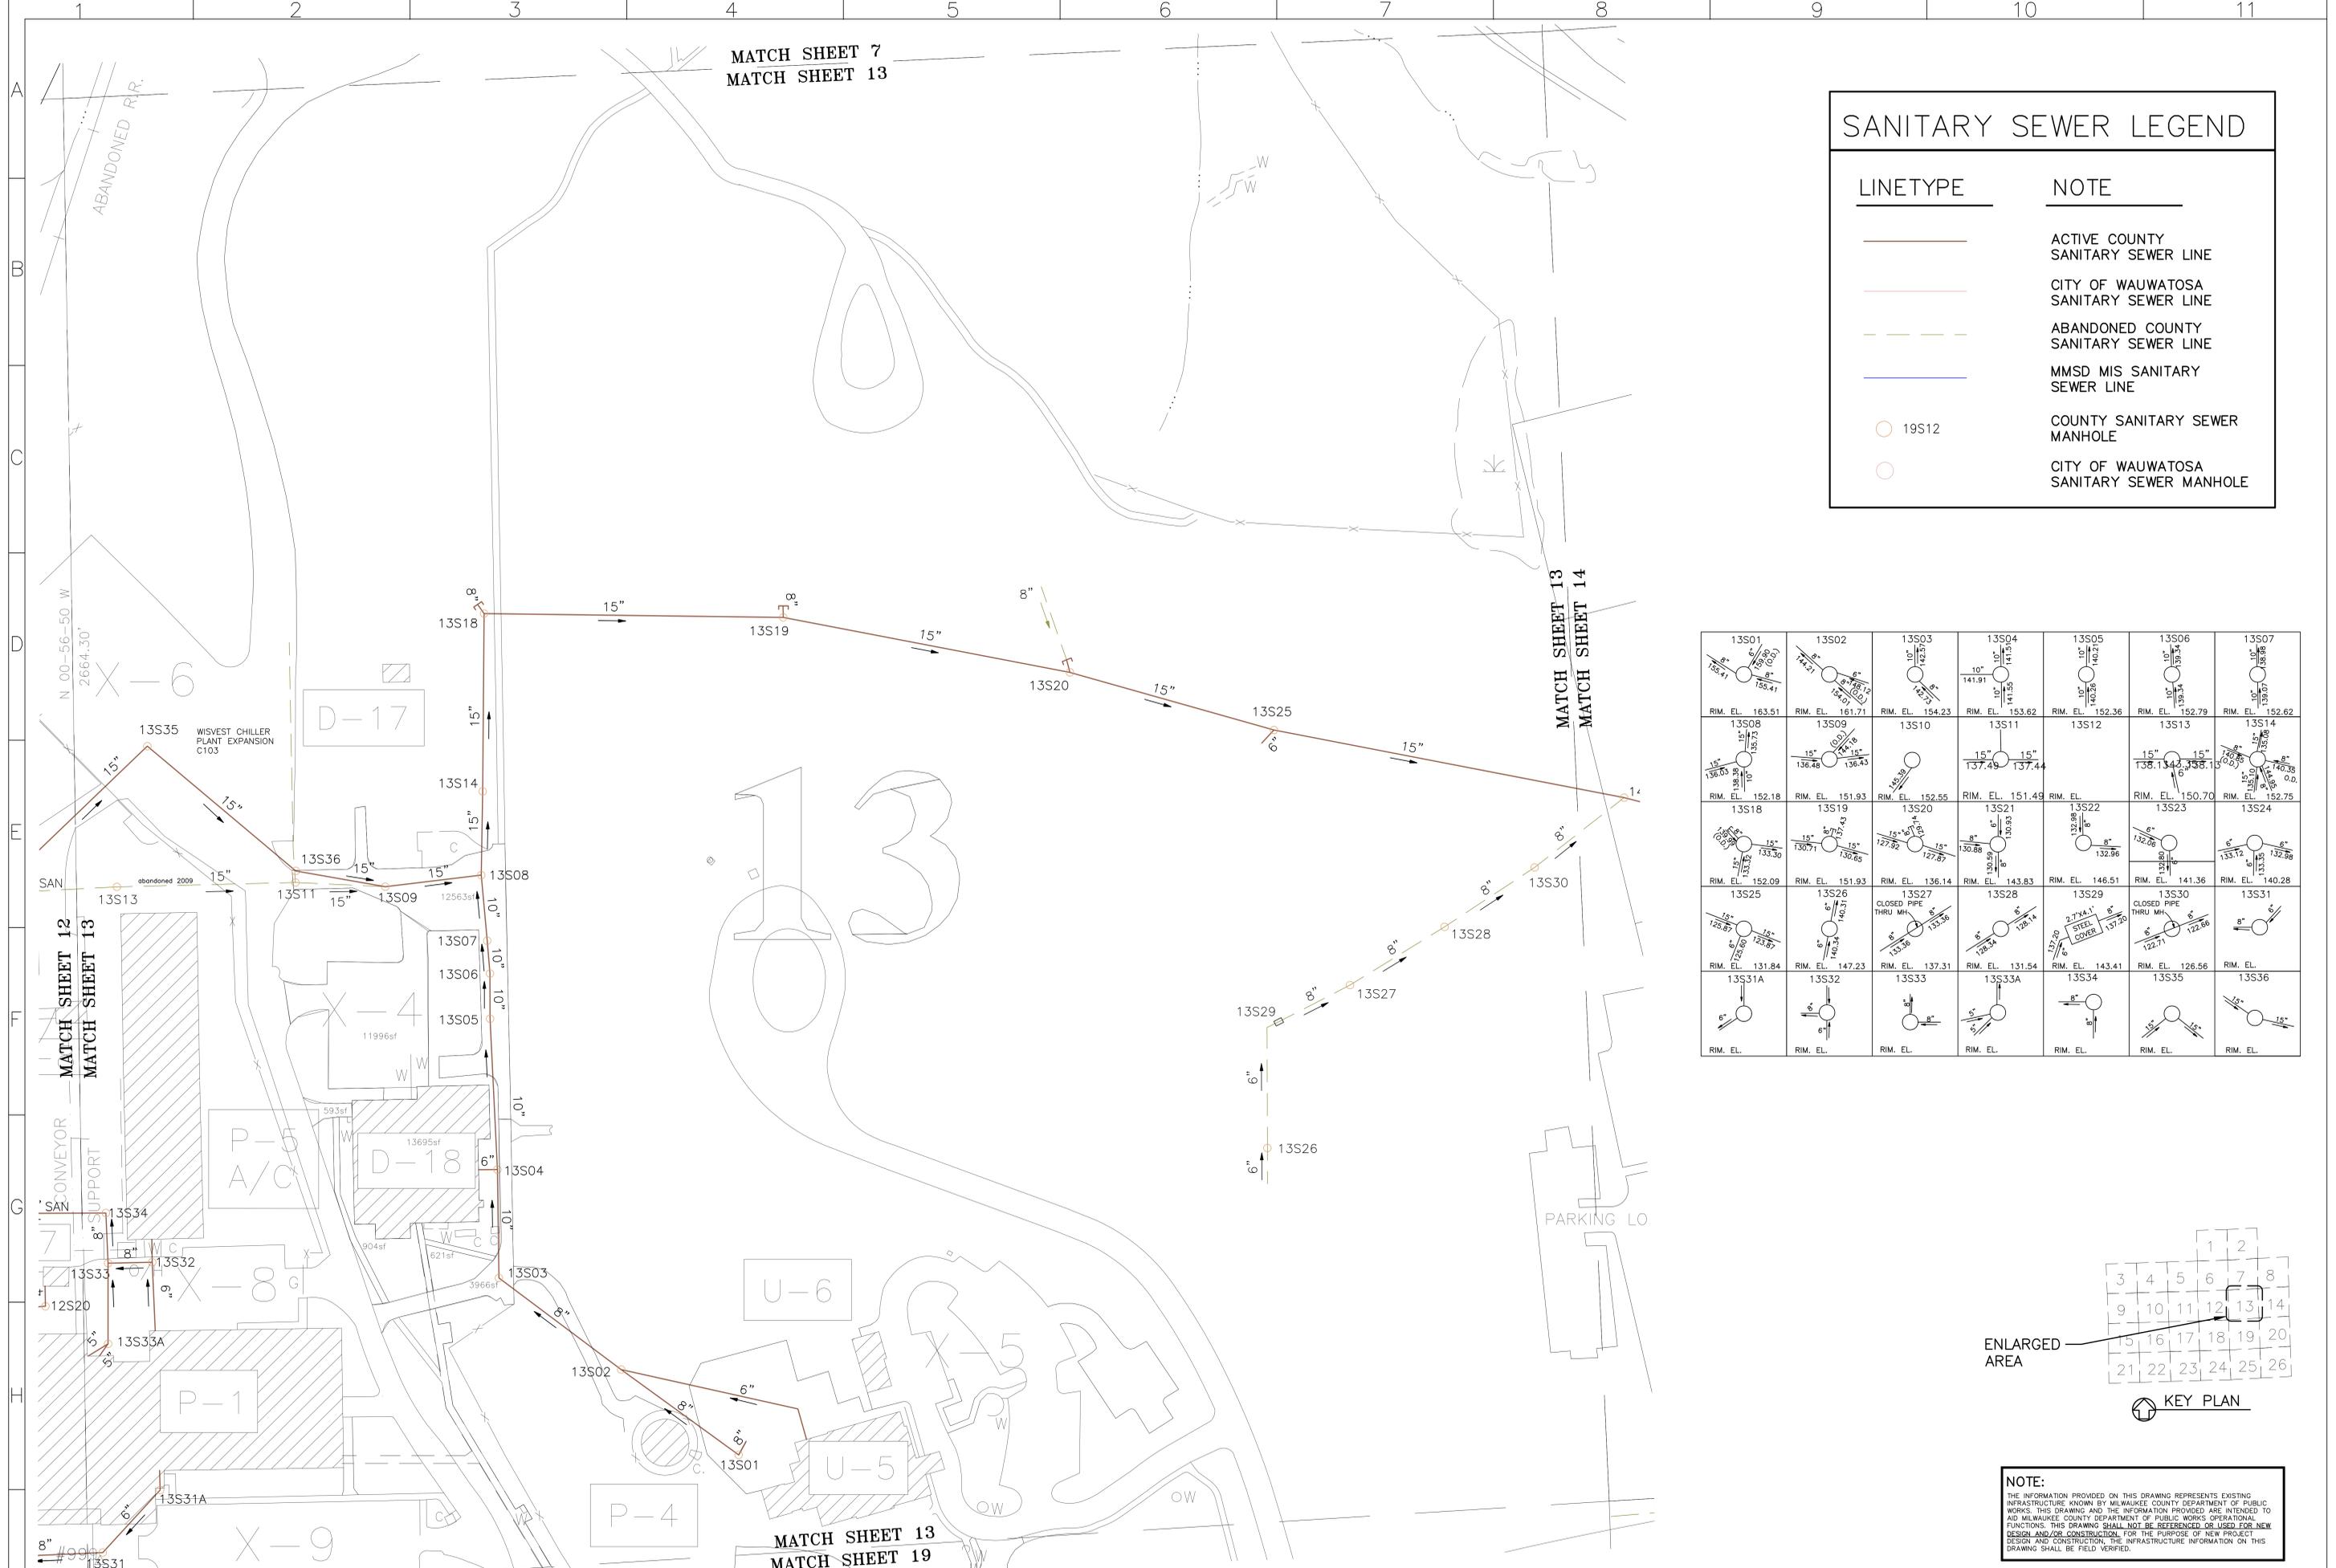


LINETYPE	NOTE
	ACTIVE COUNTY SANITARY SEWER LINE
	CITY OF WAUWATOSA SANITARY SEWER LINE
	ABANDONED COUNTY SANITARY SEWER LINE
	MMSD MIS SANITARY SEWER LINE
	19S12 COUNTY SANITARY SEWER MANHOLE
	CITY OF WAUWATOSA SANITARY SEWER MANHOLE

RIM. EL. 163.51	RIM. EL. 151.71	RIM. EL. 154.23	RIM. EL. 153.62	RIM. EL. 152.36	RIM. EL. 152.79	RIM. EL. 152.62
RIM. EL. 152.18	RIM. EL. 151.93	RIM. EL. 152.55	RIM. EL. 151.48	RIM. EL.	RIM. EL. 150.70	RIM. EL. 152.75
RIM. EL. 152.09	RIM. EL. 151.93	RIM. EL. 136.14	RIM. EL. 143.83	RIM. EL. 146.51	RIM. EL. 141.36	RIM. EL. 140.28
RIM. EL. 131.84	RIM. EL. 147.23	RIM. EL. 137.31	RIM. EL. 131.54	RIM. EL. 143.41	RIM. EL. 126.56	RIM. EL.
RIM. EL.						

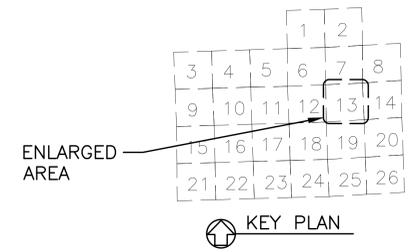


NOTE:
 THE INFORMATION PROVIDED ON THIS DRAWING REPRESENTS EXISTING INFRASTRUCTURE KNOWN BY MILWAUKEE COUNTY DEPARTMENT OF PUBLIC WORKS. THIS DRAWING AND THE INFORMATION PROVIDED ARE INTENDED TO AID MILWAUKEE COUNTY DEPARTMENT OF PUBLIC WORKS OPERATIONAL FUNCTIONS. THIS DRAWING SHALL NOT BE REFERENCED OR USED FOR NEW DESIGN AND/OR CONSTRUCTION FOR THE PURPOSE OF NEW PROJECT DESIGN AND CONSTRUCTION. THE INFRASTRUCTURE INFORMATION ON THIS DRAWING SHALL BE FIELD VERIFIED.

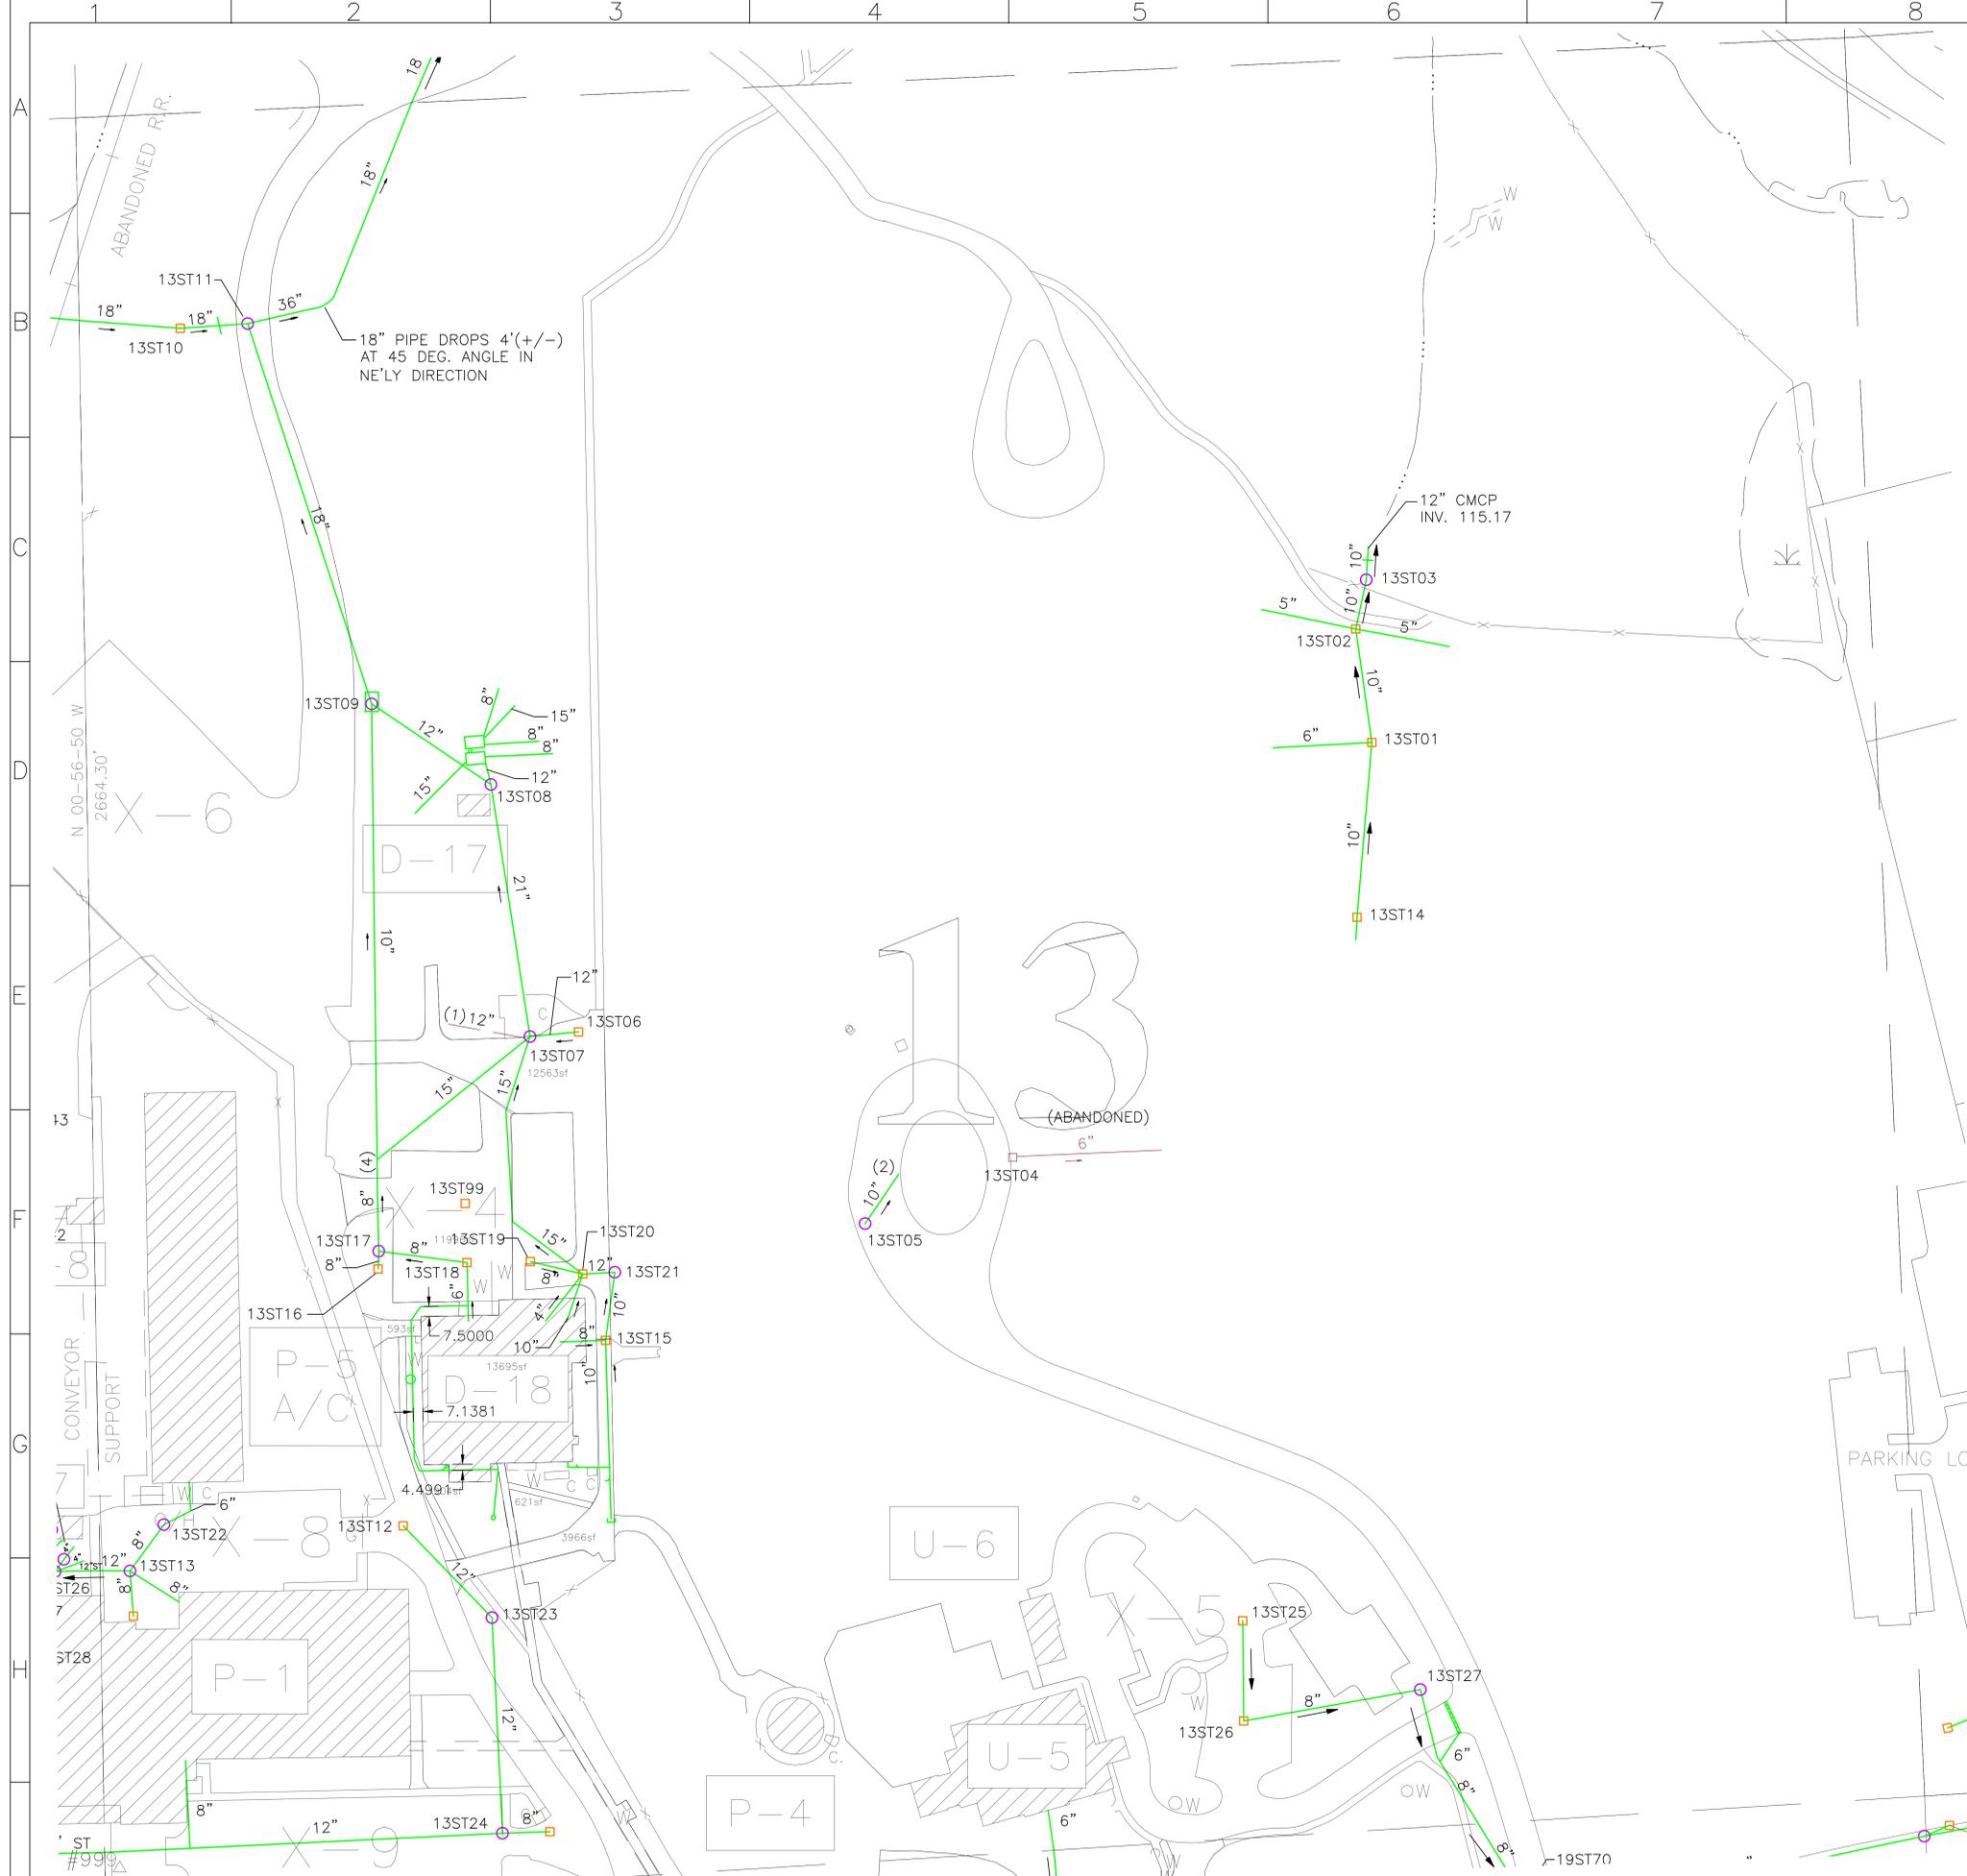


(T) = TRAPPED PIPE IN C.B., UPPER PIPE (PLUG) ELEV. GIVEN (SEE SHEET NO.1)

13ST01 RIM. EL. 132.89	13ST02 RIM. EL. 126.98	13ST03 RIM. EL. 126.15	13ST04 RIM. EL. 152.75	13ST05 RIM. EL. 156.90	13ST06 RIM. EL. 152.07	13ST07 RIM. EL. 152.50
13ST08 RIM. EL. 151.58	13ST09 RIM. EL. 151.18	13ST10 RIM. EL. 134.34	13ST11 RIM. EL. 133.09	13ST12 RIM. EL. 154.40	13ST13 RIM. EL. 157.9	13ST14 RIM. EL. 144.00
13ST15 RIM. EL. 152.80	13ST16 RIM. EL. 153.09	13ST17 RIM. EL. 146.91	13ST18 RIM. EL. 152.26	13ST19 RIM. EL. 151.95	13ST20 RIM. EL. 152.18	13ST21 RIM. EL. 152.33
13ST22 RIM. EL.	13ST23 RIM. EL.	13ST24 RIM. EL.	13ST25 RIM. EL.	13ST26 RIM. EL.	13ST27 RIM. EL.	

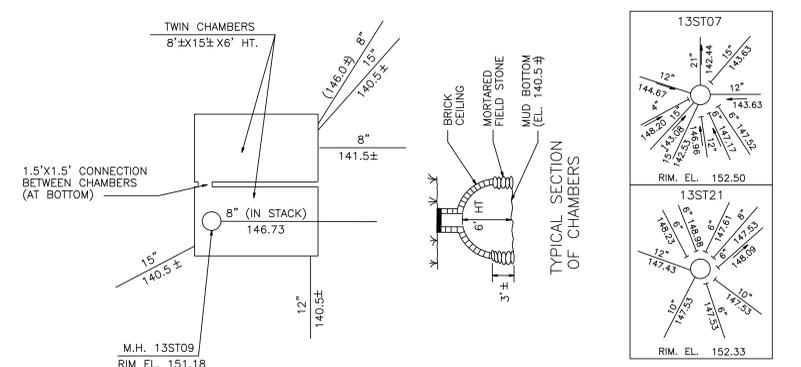



**STORM WATER STORAGE CHAMBERS
AT M.H. 13ST09**
(SIZE & ELEV. OF PIPES IN NORTH CHAMBER)
HAVE BEEN ESTIMATED FROM PHOTOS

- NOTES:
- (1) THIS LINE IS BELIEVED TO BE ABANDONED FROM A FORMER BUILDING.
 - (2) LOCATION AND TERMINATION OF LINE FROM M.H. 13ST05 COULD NOT BE DETERMINED.
 - (3) 13ST20 & 21 ARE FULL OF SILT AND ARE DETERIORATED STRUCTURES. DRAINAGE OUTLET FROM THESE STRUCTURES COULD NOT BE ASCERTAIN. PROBABLE OUTLET SHOWN ON PLAN (CB9 TO 13ST07 THRU BUILDING.)
 - (4) FLOW FROM 13ST17 TO NORTH COULD NOT BE TRACED. IT MOST LIKELY DISCHARGES INTO 13ST07 VIA 15" (SEE PLAN)

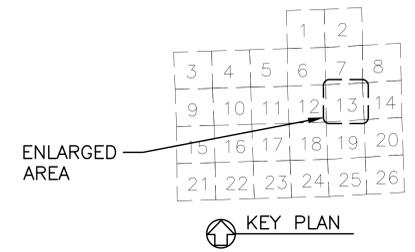


NOTE:
THE INFORMATION PROVIDED ON THIS DRAWING REPRESENTS EXISTING INFRASTRUCTURE KNOWN BY MILWAUKEE COUNTY DEPARTMENT OF PUBLIC WORKS. THIS DRAWING AND THE INFORMATION PROVIDED ARE INTENDED TO AID MILWAUKEE COUNTY DEPARTMENT OF PUBLIC WORKS OPERATIONAL FUNCTIONS. THIS DRAWING SHALL NOT BE REFERENCED OR USED FOR NEW DESIGN AND/OR CONSTRUCTION FOR THE PURPOSE OF NEW PROJECT DESIGN AND CONSTRUCTION. THE INFRASTRUCTURE INFORMATION ON THIS DRAWING SHALL BE FIELD VERIFIED.


 


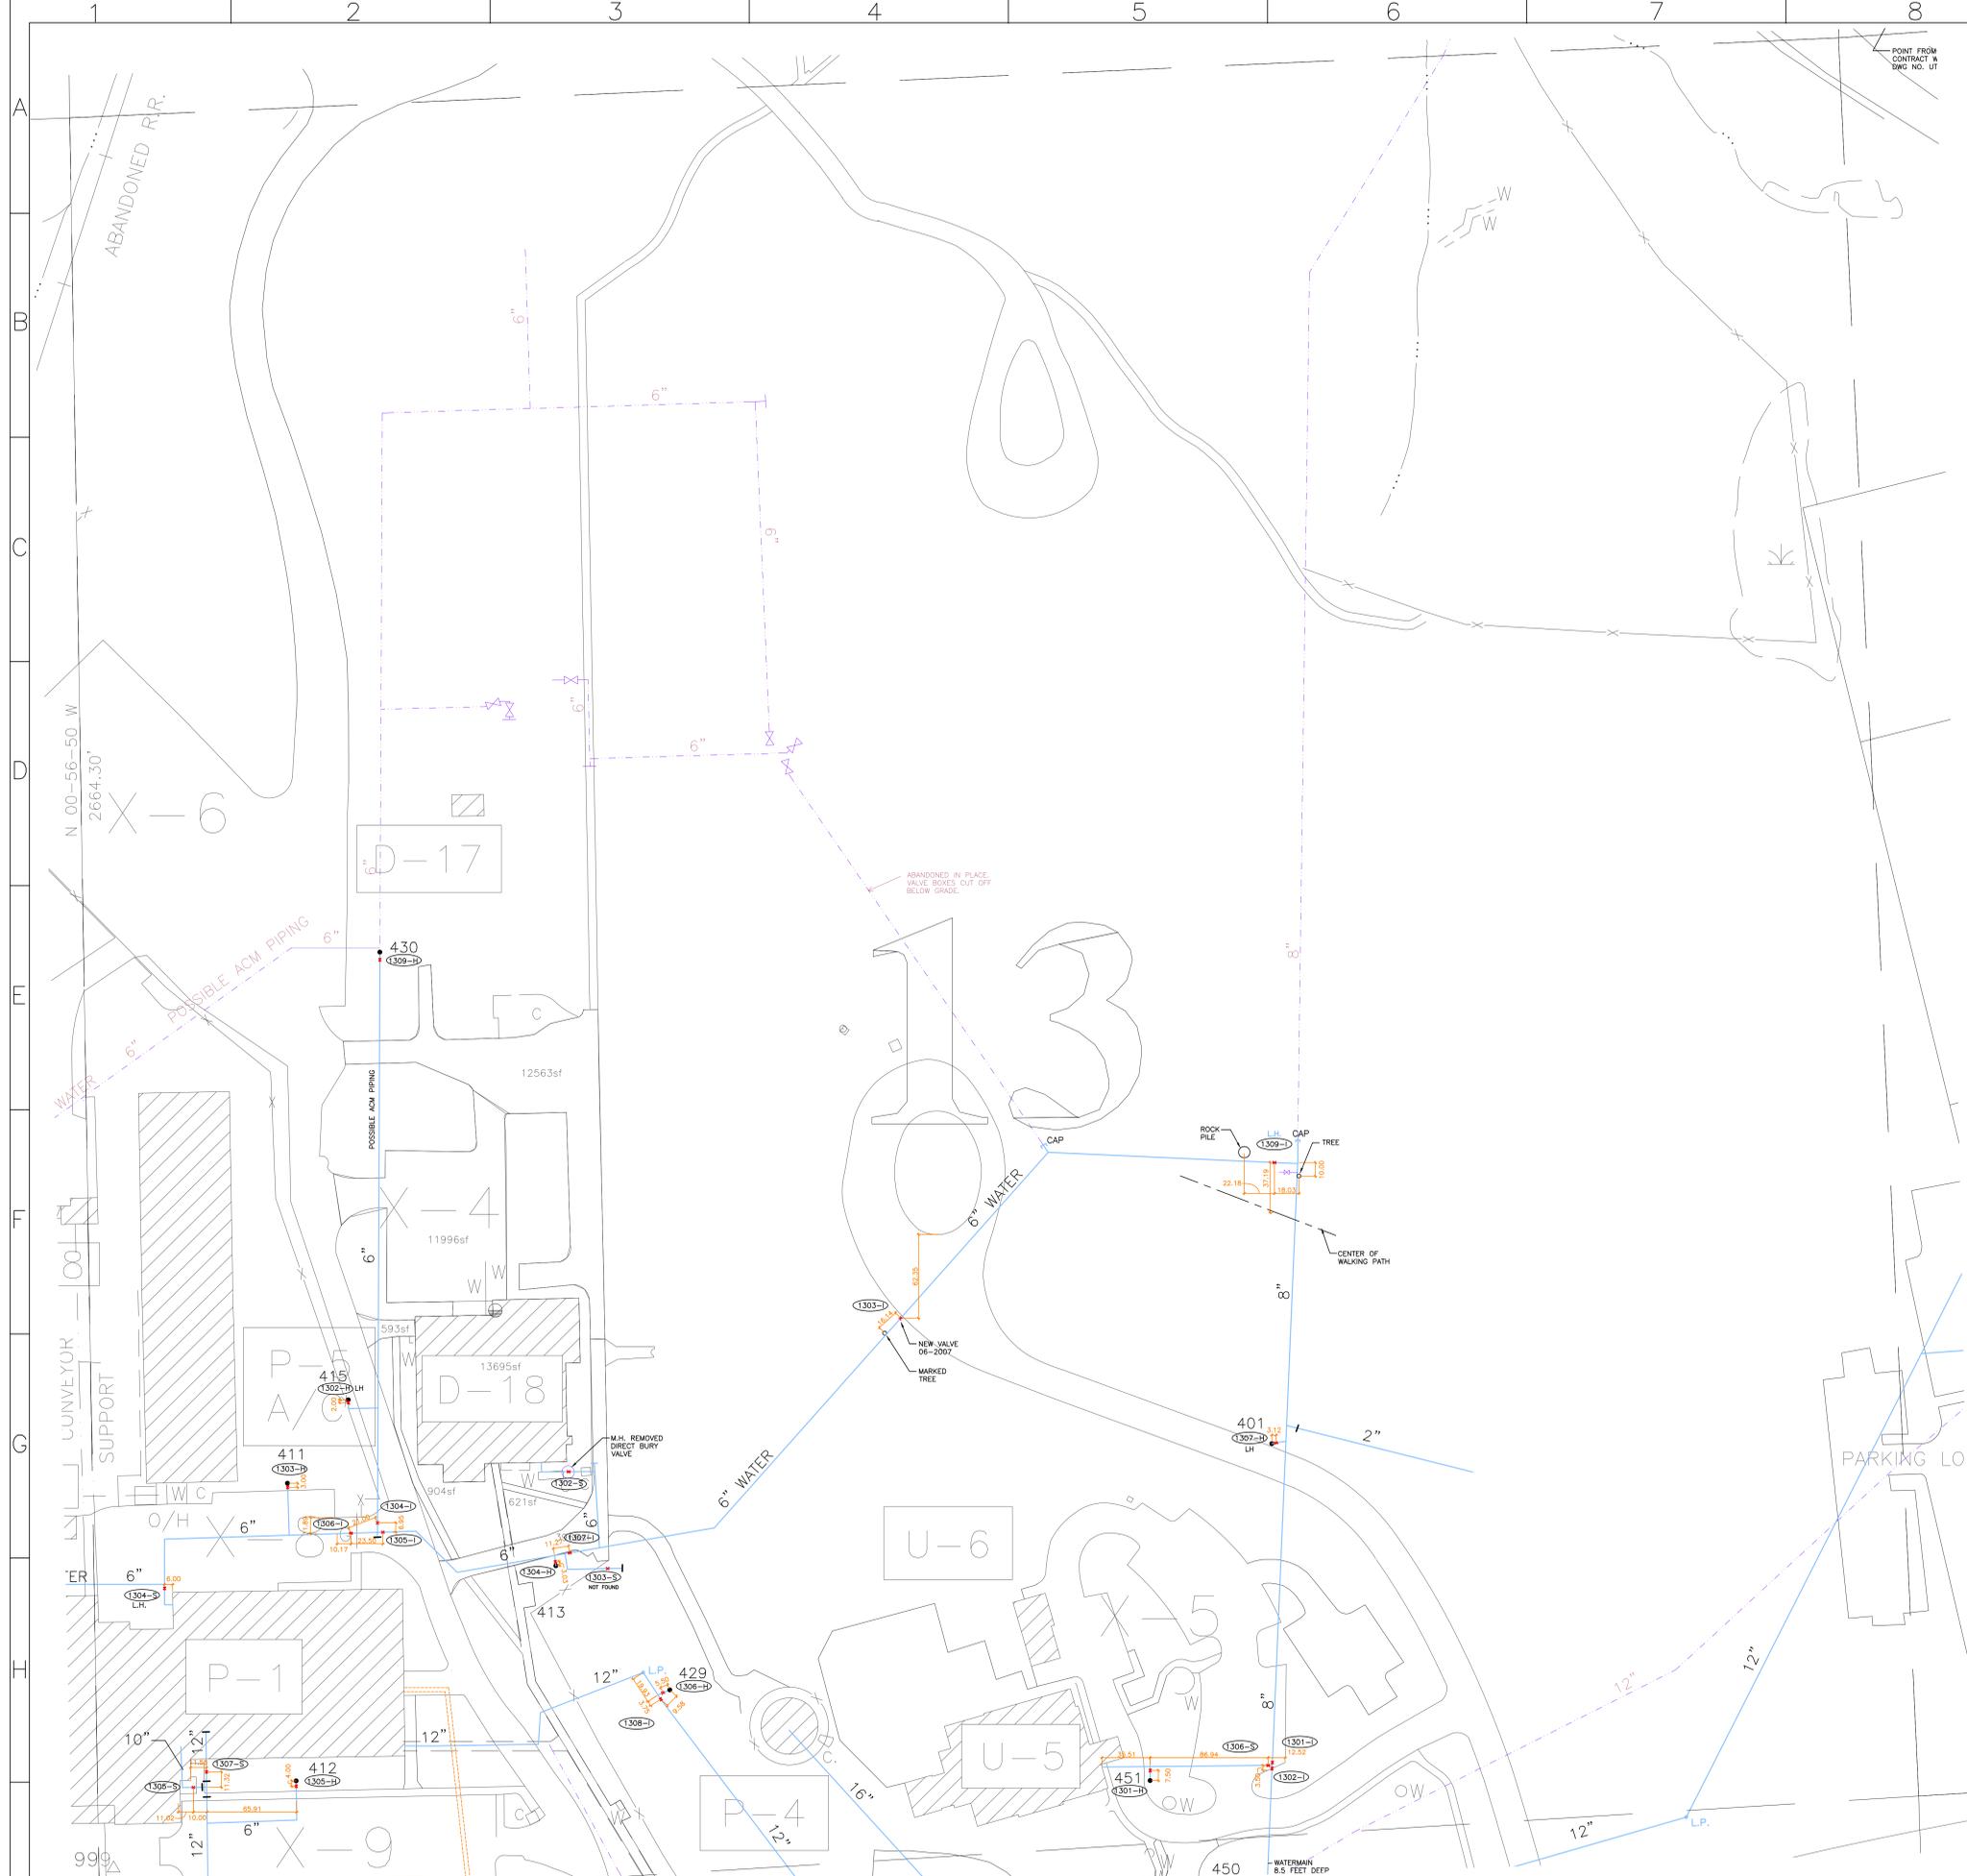


POWERPLANT DETAIL (N.T.S.)

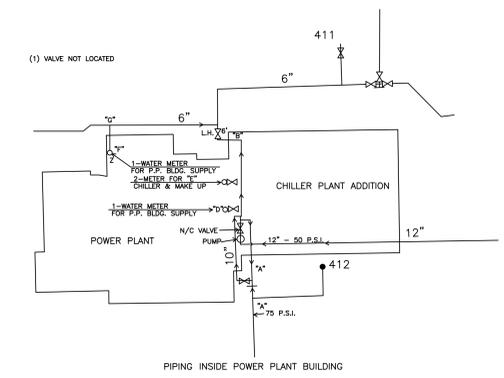

ENLARGED VALVE DETAILS
SCALE: 1"=25'

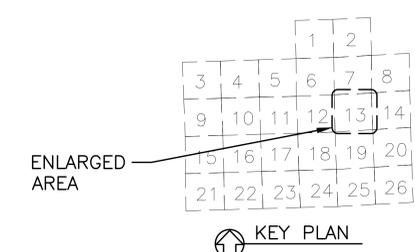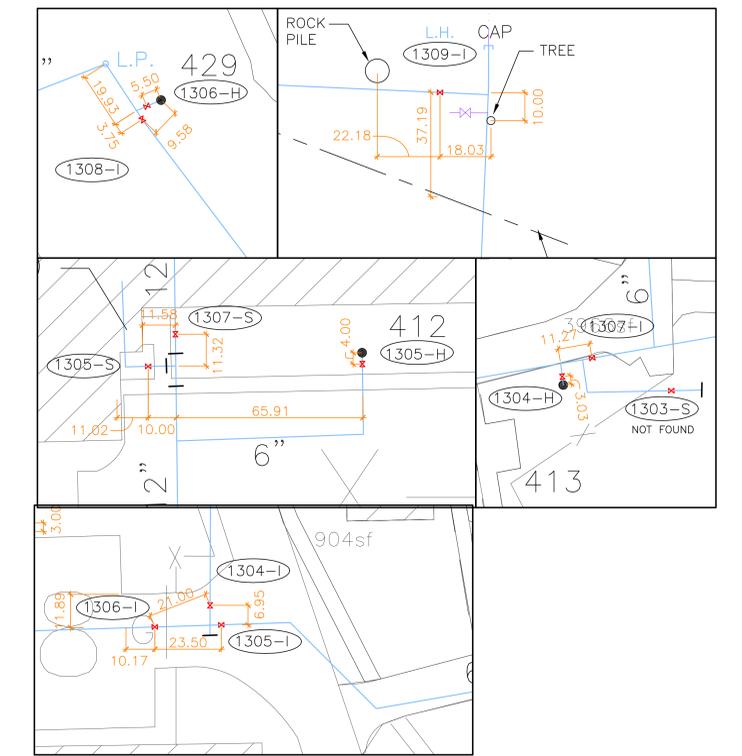

NOTE:
THE INFORMATION PROVIDED ON THIS DRAWING REPRESENTS EXISTING INFRASTRUCTURE KNOWN BY MILWAUKEE COUNTY DEPARTMENT OF PUBLIC WORKS. THIS DRAWING AND THE INFORMATION PROVIDED ARE INTENDED TO AID MILWAUKEE COUNTY DEPARTMENT OF PUBLIC WORKS OPERATIONAL FUNCTIONS. THIS DRAWING SHALL NOT BE REFERENCED OR USED FOR NEW DESIGN AND/OR CONSTRUCTION FOR THE PURPOSE OF NEW PROJECT DESIGN AND CONSTRUCTION. THE INFRASTRUCTURE INFORMATION ON THIS DRAWING SHALL BE FIELD VERIFIED.

 

SHEET NO. 13 OF 26	PROJECT NO. W13	TITLE MILWAUKEE COUNTY GROUNDS POTABLE WATER SYSTEM	SCALE: 1"=50'	DRAWN BY: BRB / MJS	REVISIONS: 08/16/06 GENERAL REVISIONS 01/15/10 GENERAL REVISIONS 06/13/12 GENERAL REVISIONS		PREPARED BY: DTPW SUPPORT SERVICES-GIS SECTION FOR MILWAUKEE COUNTY DEPARTMENT OF TRANSPORTATION AND PUBLIC WORKS 10310 WATERTOWN PLANK ROAD MILWAUKEE, WISCONSIN 53226
SHEET SIZE E	FILE NO.		DATE: 06/13/12	CHECKED BY: TOM T.			